

U.S. VIRGIN ISLANDS PARCEL NO. 390 **ESTATE ANNA'S RETREAT** ST. THOMAS, VI 00802 **VICINITY MAP** P.I.N. 105-602-018-900 142-A 145 PROJECT SITE: PARCEL NO. 390 173-237 **ESTATE ANNA'S RETREAT** ST. THOMAS, VI 00802 173-238 P.I.N. 105-602-018-900 173-239 173-290 173-288 173-286 **LOCATION MAP**

INDEX OF DRAWINGS SHEET NAME SHEET NUMBER **COVER SHEET** PROJECT DATA CODE SUMMARY LIFE SAFETY PLAN ABBREVIATIONS & SYMBOLS ACCESSIBILITY COMPLIANCE ACCESSIBILITY COMPLIANCE ARCHITECTURAL SITE PLAN IDENTIFICATION FLOOR PLAN DIMENSION FLOOR PLAN REFLECTED CEILING PLAN **ROOF PLAN** FINISH PLAN **EQUIPMENT LAYOUT PLAN** FURNITURE AND FIXTURES PLAN ENLARGED FLOOR PLANS SOUTH ELEVATION & EAST ELEVATION NORTH ELEVATION & WEST ELEVATION **BUILDING SECTIONS BUILDING SECTIONS BUILDING SECTIONS BUILDING SECITONS BUILDING SECTIONS** TYPICAL WALL TYPES ROOF DETAILS WINDOW DETAILS DOOR & FRAME DETAILS APPARATUS BAY DOOR DETAILS SLAB EDGE & TRENCH DRAWIN DETAILS TURNOUT GEAR STORAGE DETAILS MILLWORK DETAILS DOOR SCHEDULE WINDOW SCHEDULE ROOM FINISH SCHEDULE **EQUIPMENT SCHEDULE** INTERIOR ELEVATIONS INTERIOR ELEVATIONS INTERIOR ELEVATIONS INTERIOR ELEVATIONS ARCHITECTURAL DEMOLITION PLAN

BOSCHULTE



PRIME ARCHITECT

JAREDIAN DESIGN GROUP

SECOND FLOOR - SUITES B24-25 ST. THOMAS, USVI 00802

340-777-1600 PHONE:

EMAIL: jarediandesigngroup@gmail.com

CONSULTING ARCHITECT

BOSCHULTE ARCHITECTURE, LLC

St. Thomas, VI 00803

phone: (340) 777-2375 e-mail: info@boschulte.com website: www.boschulte.com



390

PROGRESS SET Description 2021.007.04 4/15/2025 Checked by

GEORGE C. SCOTT FIRE STATION

PARCEL NO. 390 **ESTATE ANNA'S RETREAT** NO. 1 NEW QUARTER ST. THOMAS, U.S. VIRGIN ISLANDS 00802 SLA PROJECT NUMBER: **ODR PROJECT NUMBER:**

> FCD (FEDERAL CONSISTENCY DETERMINATION) 30% PACKAGE

PROJECT TEAM:









Boschulte Architecture, LLC

Jeffrey Boschulte, AIA, NCARB

PRIME ARCHITECT

ARCHITECTURAL CONSULTANT

Government of the United States Virgin Islands

HONORABLE ALBERT BRYAN, JR.

GOVERNOR

OWNER

GOVERNMENT HOUSE, ST. THOMAS 5047 (21-22) KONGENS GADE ST. THOMAS, VI 00802-6487

340-774-0001 Albert Bryan, Jr. Governor Office of Disaster Recovery

HONORABLE Adrienne L. Williams-Octalien

DIRECTOR

AGENCY

VI PUBLIC FINANCE AUTHORITY 1000 KING STREET, SUITE NO. 6 CHRISTIANSTED, VI 00820-4905

PHONE: (340) 778-8135 Michael D. Vante mdvante@usvipfa.com VI Fire and Emergency Services

HON. ANTONIO STEVENS

DIRECTOR

VI FIRE & EMERGENCY MEDICAL SERVICES 1005 ESTATE TAARNEBERG ST. THOMAS, VI 00802

PHONE: FAX: ATT:

EMAIL:

Jaredian Design Group

John P. Woods, AIA, NCARB

PRINCIPAL

5333 RAADETS GADE SUITE 14 ST. THOMAS, VI 00802-6900

PHONE: 340-777-1600 FAX: ATT: John P. Woods admin@jaredian.com PO BOX 303190 ST. THOMAS, VI 00803

PRINCIPAL

340-777-2375 Jeffrey T. Boschulte info@boschulte.com **COVER SHEET**

G000

GENERAL NOTES

- 1. PROJECT IDENTIFICATION: HURRICANE REPAIRS FOR GEORGE C. SCOTT FIRE STATION
- 2. SITE ZONING: C-COMMERCIAL (PROPOSED USE: FIRE STATION)
- OWNER: GOVERNMENT OF THE VIRGIN ISLANDS
- USER AGENCY: VIRGIN ISLANDS FIRE & EMERGENCY MEDICAL SERVICES (V.I.F.E.M.S.)
- ARCHITECT: JAREDIAN DESIGN GROUP
- 6. ARCHITECTURAL CONSULTANT: BOSCHULTE ARCHITECTURE, LLC
- 7. KEEP ACCESS EASEMENTS, DRIVEWAYS, AND ENTRANCES SERVING PREMISES AND ADJACENT PROPERTIES CLEAR AND AVAILABLE TO OWNER AND EMERGENCY VEHICLES AT ALL TIMES. DO NOT USE THESE AREAS FOR PARKING OR STORAGE OF MATERIALS.
- COORDINATE, SCHEDULE, AND APPROVE PERMANENT AND TEMPORARY UTILITIES, INCLUDING THOSE NECESSARY TO MAKE CONNECTIONS FOR TEMPORARY SERVICES.
- 9. DO NOT DISTURB PORTIONS OF THE SITE BEYOND AREAS IN WHICH THE WORK IS
- 10. REMOVE WASTE MATERIALS FROM PROJECT SITE AND LEGALLY DISPOSE OF THEM IN A LANDFILL ACCEPTABLE TO AUTHORITIES HAVING JURISDICTION. CONTRACTOR SHALL BE RESPONSIBLE FOR REMOVAL AND LEGAL DISPOSAL OFF-SITE FOR ALL DEMOLITION AND CONSTRUCTION WASTE DEBRIS, AND FOR ANY DUMPSTER, TRUCKING AND LANDFILL
- 11. ALL WORK DONE SHALL COMPLY WITH THE LATEST EDITION OF THE VIRGIN ISLANDS BUILDING CODE.
- 12. JOB SITE VISITS BY THE OWNER OR ARCHITECT DO NOT CONSTITUTE AN OFFICIAL INSPECTION UNLESS SPECIFICALLY REQUESTED BY THE CONTRACTOR.
- 13. THE ARCHITECT SHALL BE NOTIFIED A MINIMUM OF 48 HOURS PRIOR TO START OF CONSTRUCTION BY THE CONTRACTOR.

MATERIALS AND PRIOR TO COMMENCING WORK. DO NOT SCALE DRAWINGS.

- 14. CONTRACTOR TO FIELD VERIFY EXISTING SURFACES PRIOR TO ORDERING OF ANY
- 15. DEVIATION FROM THE CONSTRUCTION DOCUMENTS WITHOUT PRIOR WRITTEN CONSENT OF THE ARCHITECT MAY BE CAUSE FOR THE WORK TO BE REJECTED BY THE ARCHITECT. THE ARCHITECT SHALL NOT BE HELD LIABLE FOR ANY DAMAGES OR INJURIES WHICH MAY OCCUR DUE TO ANY UNAPPROVED DEVIATION FROM THE CONSTRUCTION DOCUMENTS.
- 16. CONTRACTOR SHALL NOTIFY CONSTRUCTION MANAGER AND/OR ARCHITECT IMMEDIATELY IN WRITING IF CONDITIONS ENCOUNTERED IN FIELD ARE DIFFERENT FROM CONDITIONS INDICATED ON DRAWINGS.





PRIME ARCHITECT

JAREDIAN DESIGN GROUP

5143 PALM PASSAGE, SECOND FLOOR - SUITES B24-25 ST. THOMAS, USVI 00802

PHONE: 340-777-1600

EMAIL: jarediandesigngroup@gmail.com

CONSULTING ARCHITECT

BOSCHULTE ARCHITECTURE, LLC

PO Box 303190 St. Thomas, VI 00803

phone: (340) 777-2375 e-mail: info@boschulte.com website: www.boschulte.com



390

PROGRESS SET 2021.007.04 4/15/2025 JTB

PROJECT DATA

G001

APPLICABLE CODES AND STANDARDS

TITLE 29 OF THE VIRGIN ISLANDS CODE (USVI)

FLOOD INSURANCE RATE MAP (FIRM):

2024 INTERNATIONAL BUIDLING CODE (IBC)

2024 INTERNATIONAL EXISTING BUILDING CODE (IEBC)

2024 INTERNATIONAL ENERGY CONSERVATION CODE (IECC)

2020 NATIONAL ELECTRIC CODE (NEC)

2024 INTERNATIONAL MECHANICAL CODE

2024 INTERNATIONAL FIRE CODE

2021 NFPA 101 LIFE SAFETY CODE

2010 ADA STANDARDS FOR ACCESSIBLE DESIGN

WIND DESIGN CRITERIA

ASCE 7-16 BASIC WIND SPEED: 165 MPH EXPOSURE CATEGORY B

SEISMIC DESIGN CRITERIA

SITE SOIL CLASSIFICATION: SITE CLASS D-"STIFF SOIL" RISK CATEGORY: II SEISMIC DESIGN CATEGORY: D

2021.007.04 390 ESTATE ANNAS ST. THOMAS, U PROGRESS SET SCHEMATIC DESIGN

2 SCHEMATIC DESIGN 04/21/2022
3 DESIGN DEVELOPMENT 06/06/2022
4 CONSTRUCTION DOCUMENTS 50% 08/22/2022 REVISIONS

Description 2021.007.04 4/15/2025 JTB

CODE SUMMARY

G002

Checked by



COMMON ABBREVIATIONS ARCH. B/ ARCHITECT **BOTTOM OF** BRG. BOTT. C/C C.J. CLR. COL. BEARING воттом CENTER-TO-CENTER CONTROL JOINT CLEAR COLUMN CONCRETE CONN. CONNECTION CONN.
CONT.
COORD.
CMU
DIM.
DIA.
DIST.
DWGS.
EL.
E.F. CONTINUOUS COORDINATE CONCRETE MASONRY UNIT DIMENSION DIAMETER DISTANCE DRAWINGS **ELEVATION** EACH FACE

EMBED. **EMBEDMENT** ENG. E.O.R. EQ. E.S. E.W. **ENGINEER** ENGINEER OF RECORD EQUAL

EACH SIDE EACH WAY EXP. EXT. **EXPANSION EXTERIOR** FABR. **FABRICATOR** F.F. FINISHED FLOOR

F.F. FFE FTG. GA. GALV. HKD. HORIZ. H.S. FINISHED FLOOR ELEVATION FOOTING GAUGE GALVANIZED HOOKED HORIZONTAL **HEADED STUD** INCHES INFORMATION

IN. INFO. INT. INTERIOR KIPS PER SQUARE INCH KSI LLH LONG LEG HORIZONTAL L.W. LONG WAYS MANUF. MANUFACTURER MAX. MAXIMUM

MECH. MECHANICAL MIN. O.C. MINIMUM ON CENTER PLATE PREFAB. PREFABRICATED PSF

POUNDS PER SQUARE FOOT PSI P.T. QTY. REF. POUNDS PER SQUARE INCH PRESSURE TREATED QUANTITY

REFERENCE REINF. REINFORCED OR REINFORCING SCHEDULE SQUARE FEET OR STEPPED FOOTING

SCH. S.F. SQU. STL. SQUARE STEEL STRUC. S.W. STRUCTURAL SHORT WAYS TOP OF

TYP. **TYPICAL** U.N.O. VCJ VMCJ UNLESS OTHERWISE NOTED VERTICAL CONTROL JOINT VERTICAL MASONRY CONTROL JOINT W/

WWF WELDED WIRE FABRIC



PRIME ARCHITECT

JAREDIAN DESIGN GROUP

5143 PALM PASSAGE, SECOND FLOOR - SUITES B24-25 ST. THOMAS, USVI 00802

PHONE: 340-777-1600

EMAIL: jarediandesigngroup@gmail.com

CONSULTING ARCHITECT

BOSCHULTE ARCHITECTURE, LLC

PO Box 303190 St. Thomas, VI 00803

phone: (340) 777-2375

e-mail: info@boschulte.com website: www.boschulte.com



390


PROGRESS SET REVISIONS 2021.007.04 4/15/2025

Checked by ABBREVIATIONS & SYMBOLS

 
JTB JTB

AS SHOWN

G004

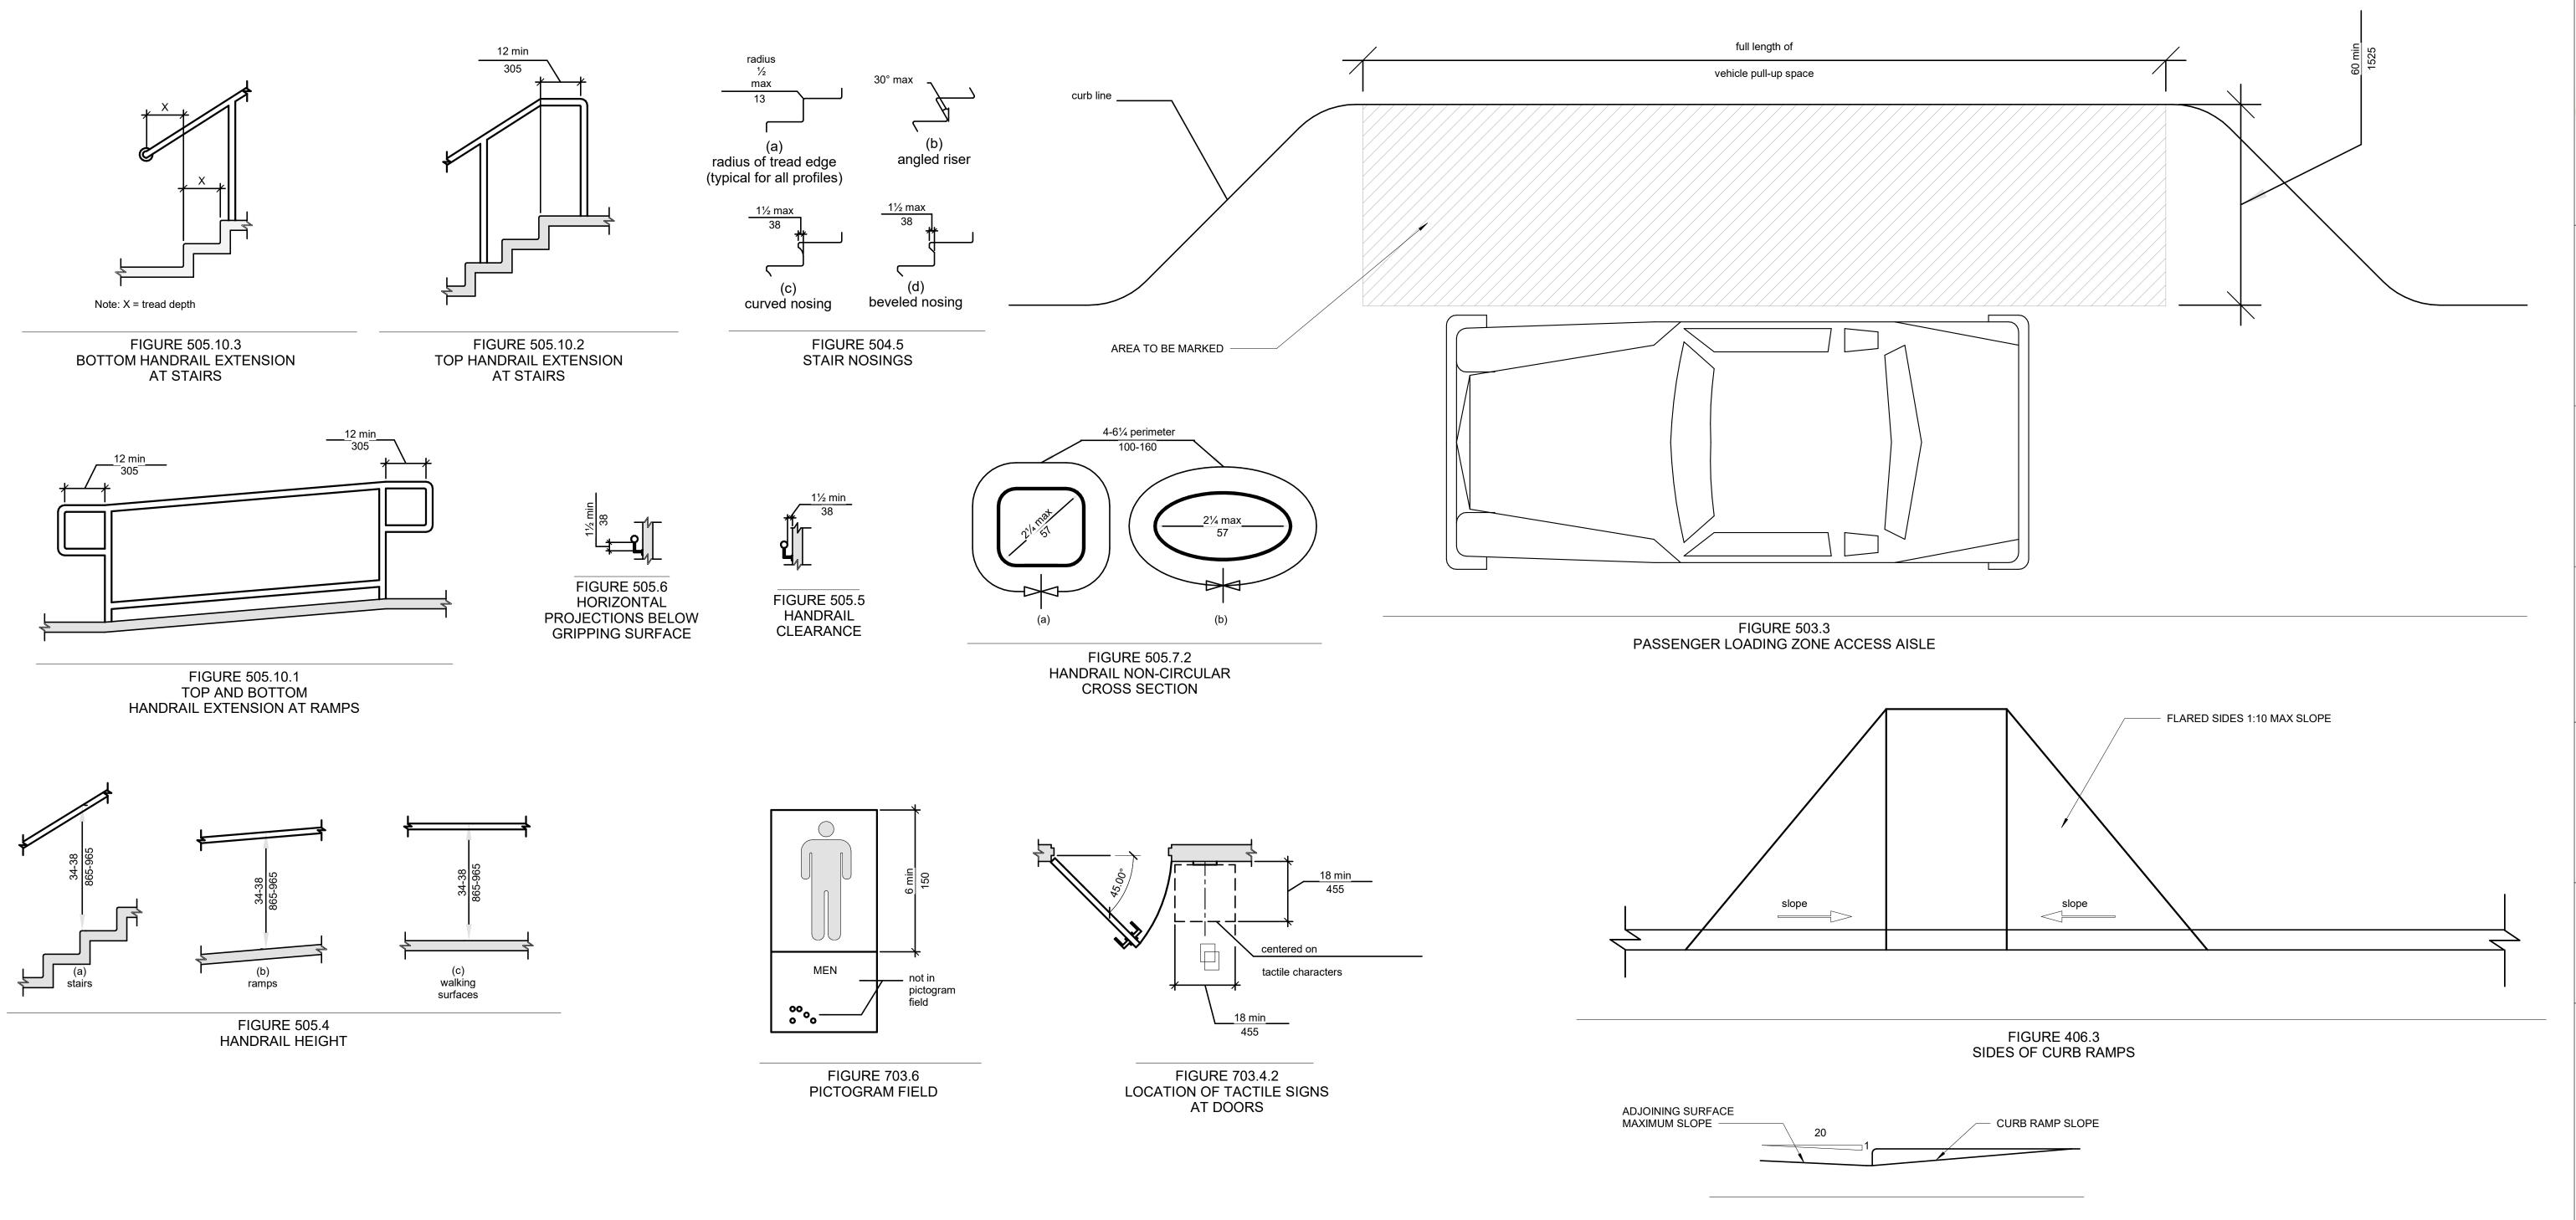









JAREDIAN DESIGN GROUP

5143 PALM PASSAGE, SECOND FLOOR - SUITES B24-25 ST. THOMAS, USVI 00802

PHONE: 340-777-1600

EMAIL: jarediandesigngroup@gmail.com

CONSULTING ARCHITECT

BOSCHULTE ARCHITECTURE, LLC

PO Box 303190 St. Thomas, VI 00803


phone: (340) 777-2375 e-mail: info@boschulte.com website: www.boschulte.com



390 PROGRESS SET REVISIONS 2021.007.04 4/15/2025 JTB Checked by

ACCESSIBILITY COMPLIANCE

G005

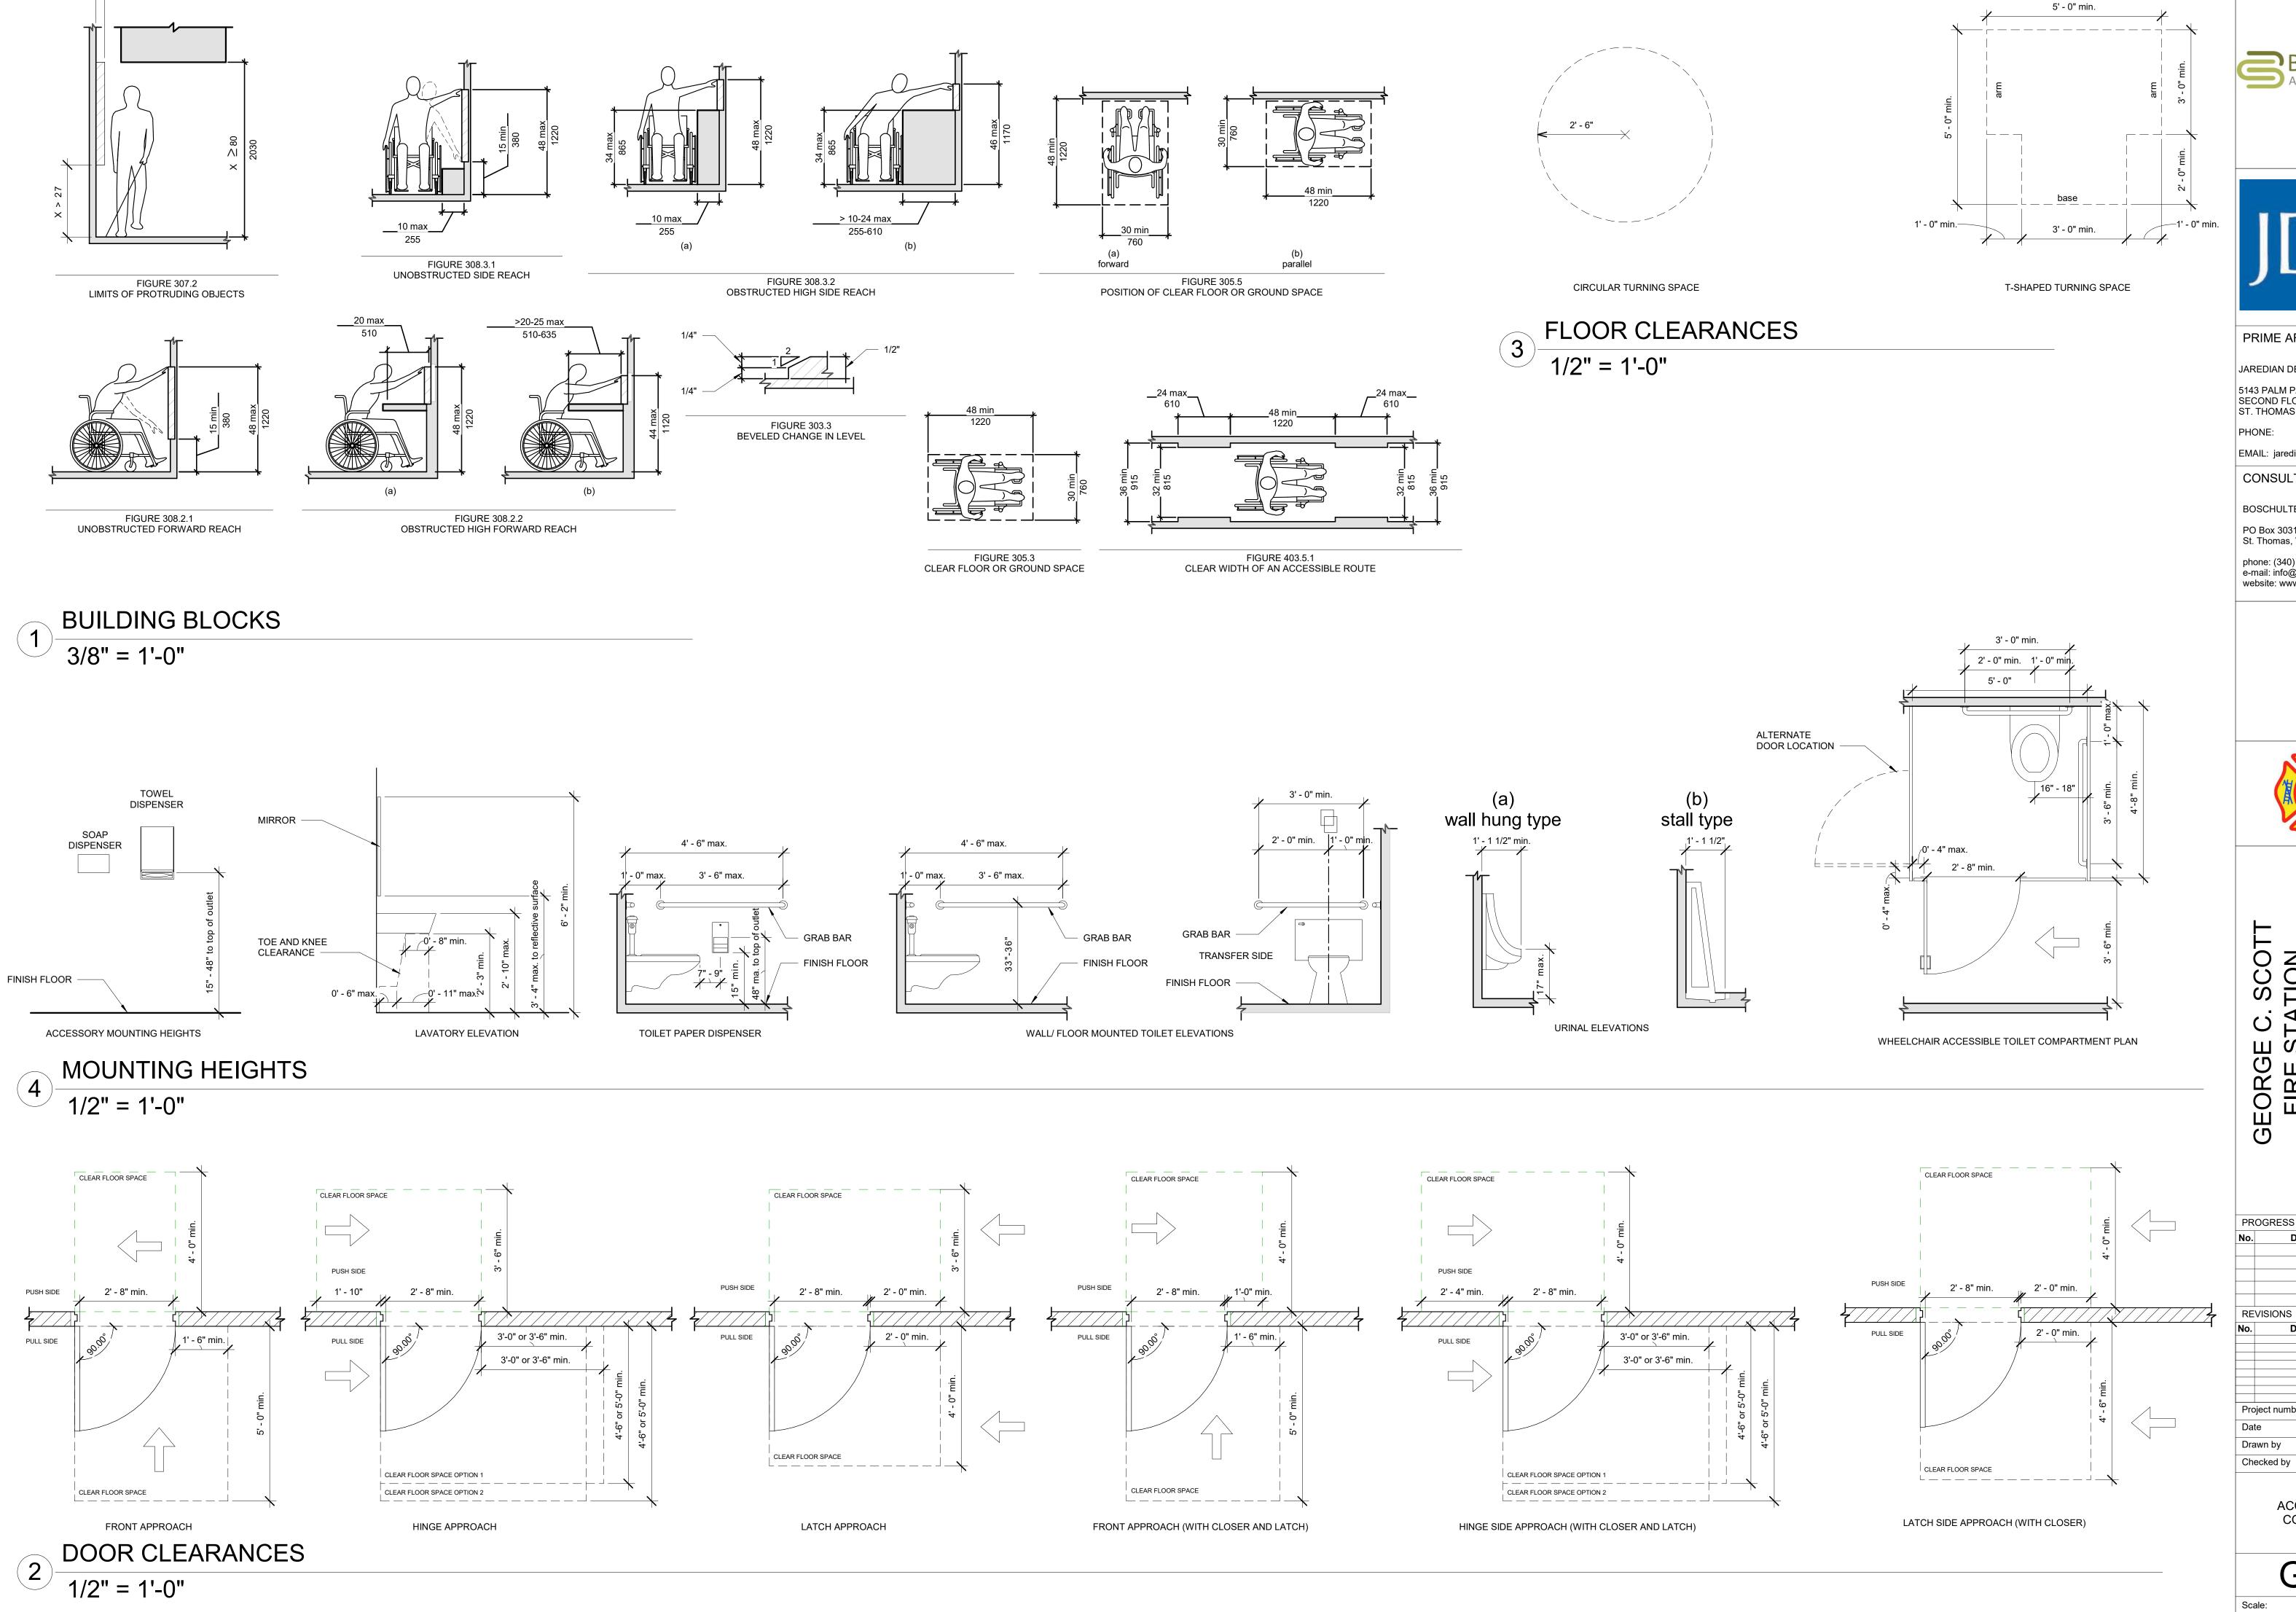

0' - 4" max

BOSCHULTE ARCHITECTURE



PRIME ARCHITECT

JAREDIAN DESIGN GROUP

5143 PALM PASSAGE, SECOND FLOOR - SUITES B24-25 ST. THOMAS, USVI 00802

PHONE: 340-777-1600

EMAIL: jarediandesigngroup@gmail.com

CONSULTING ARCHITECT

BOSCHULTE ARCHITECTURE, LLC

PO Box 303190 St. Thomas, VI 00803

phone: (340) 777-2375 e-mail: info@boschulte.com

website: www.boschulte.com




390 PROGRESS SET REVISIONS


2021.007.04 4/15/2025 JTB


ACCESSIBILITY COMPLIANCE


G006



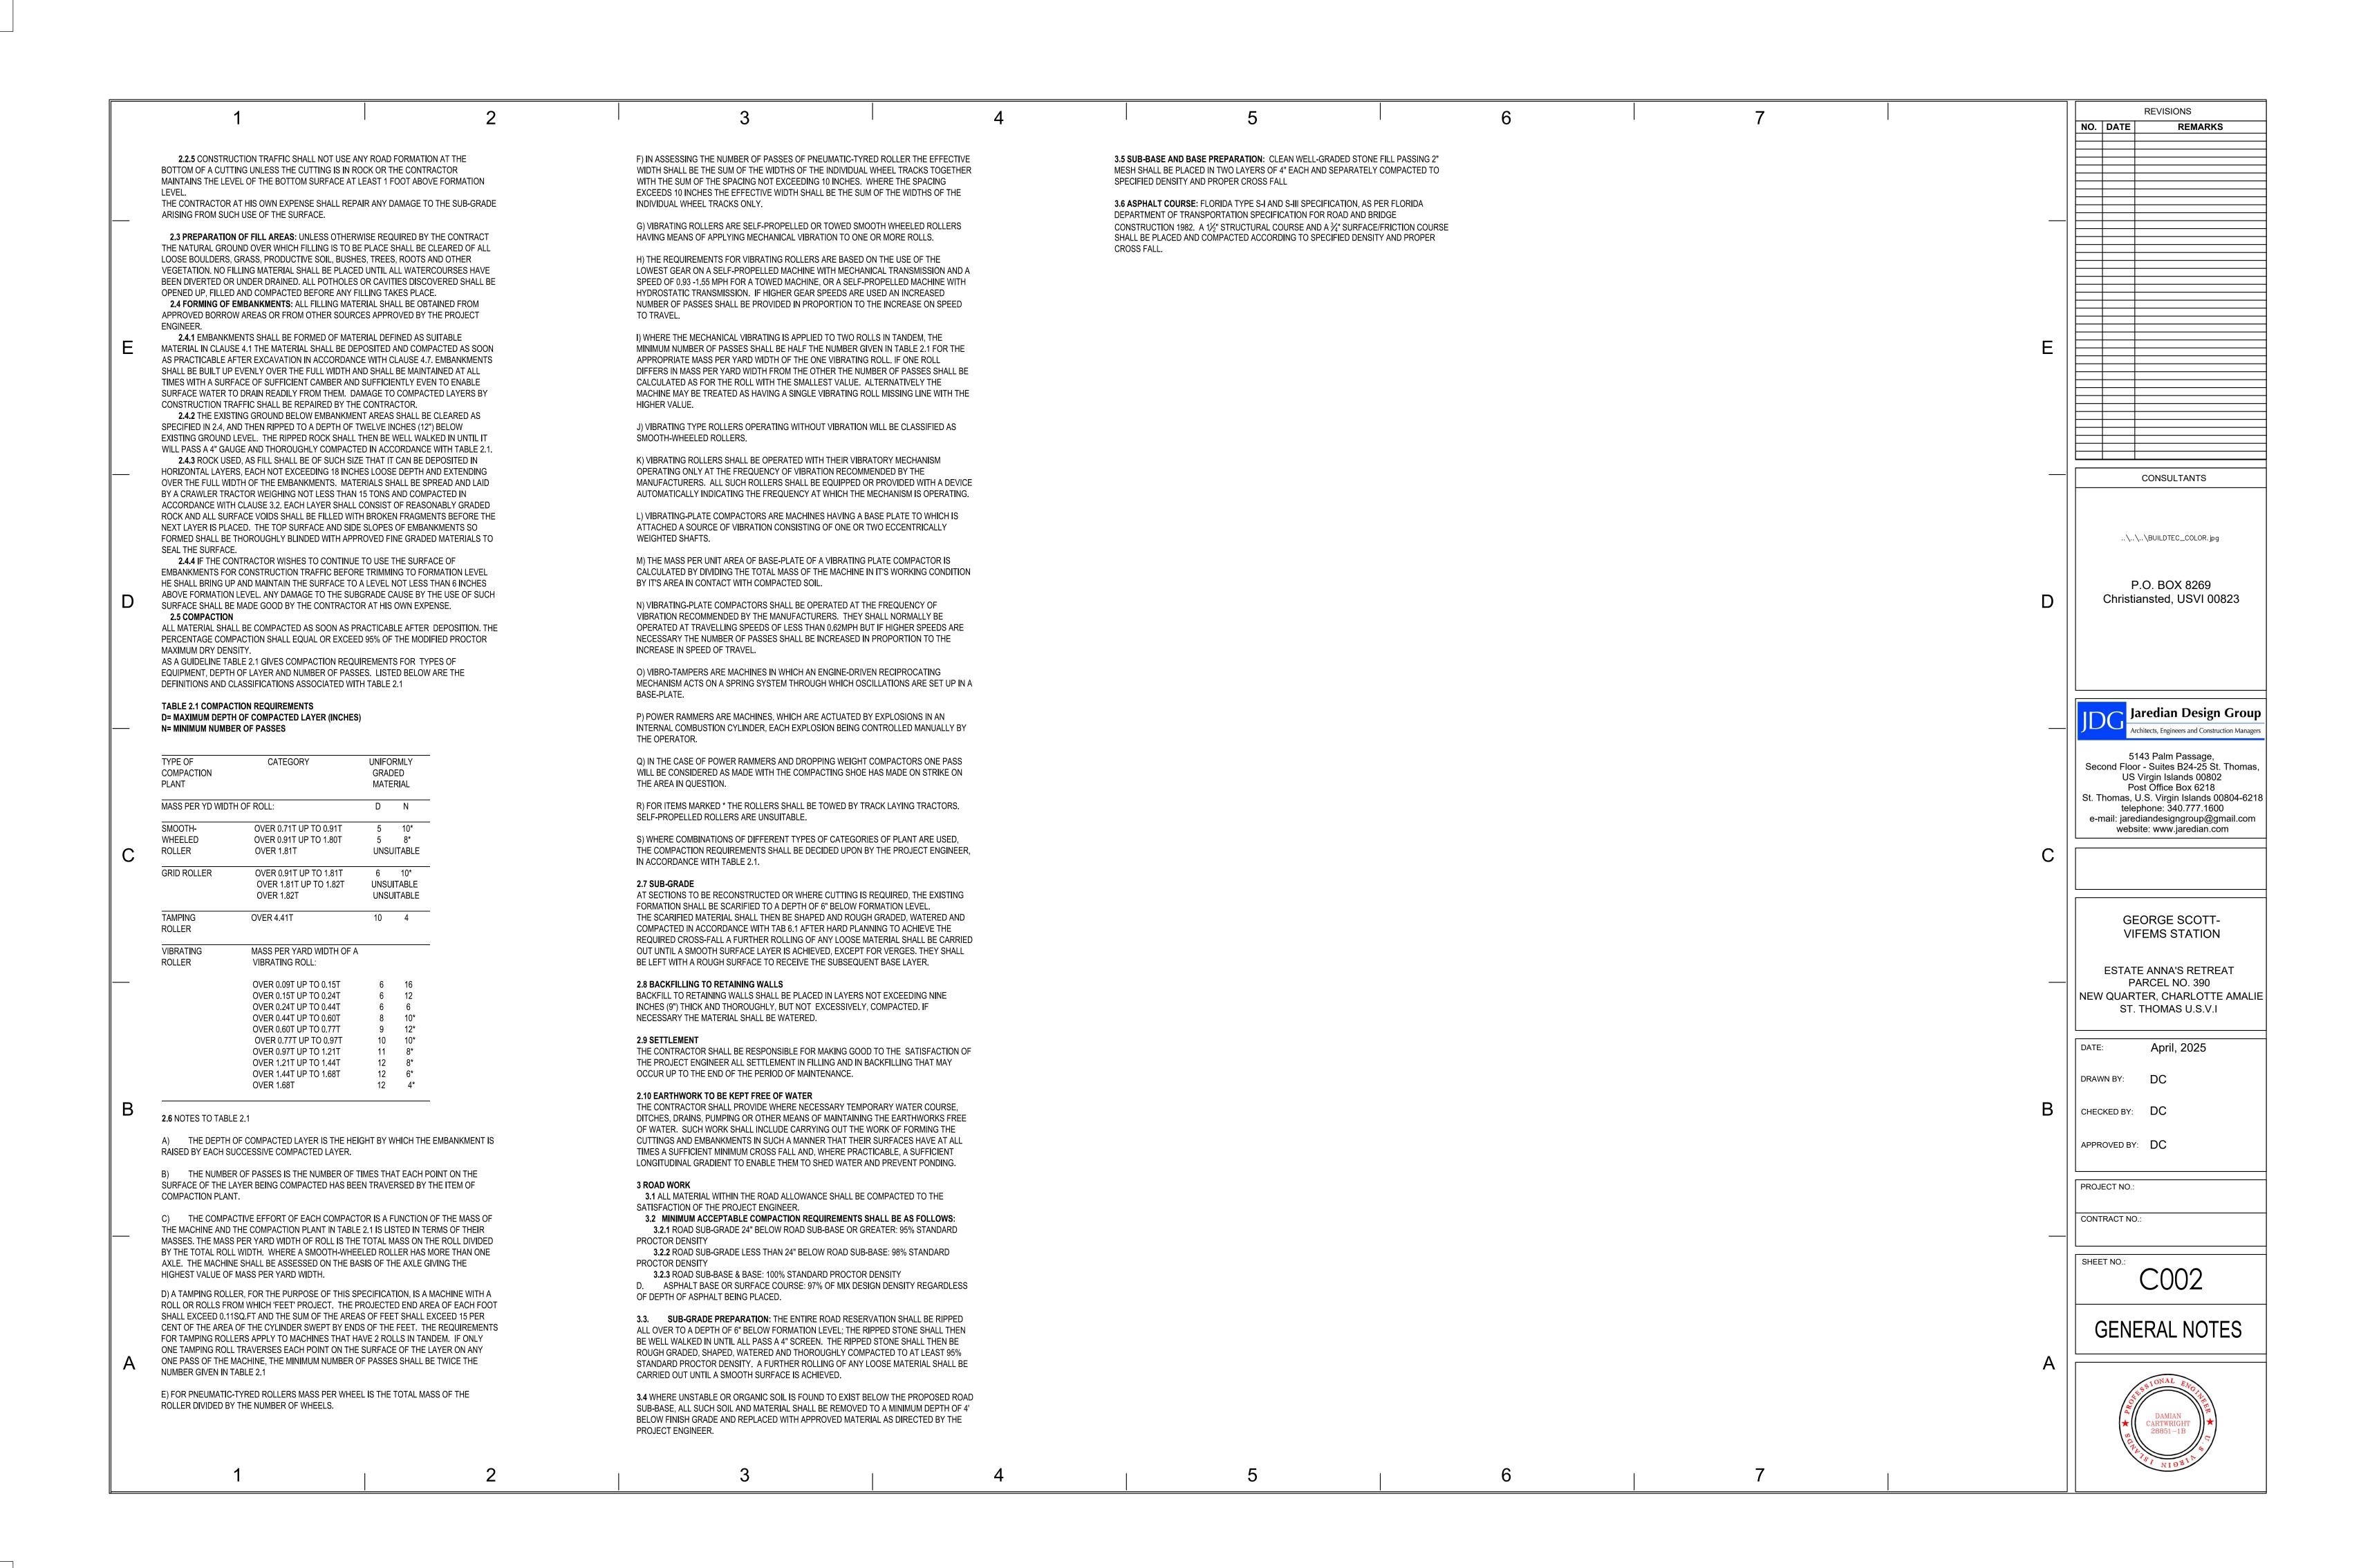


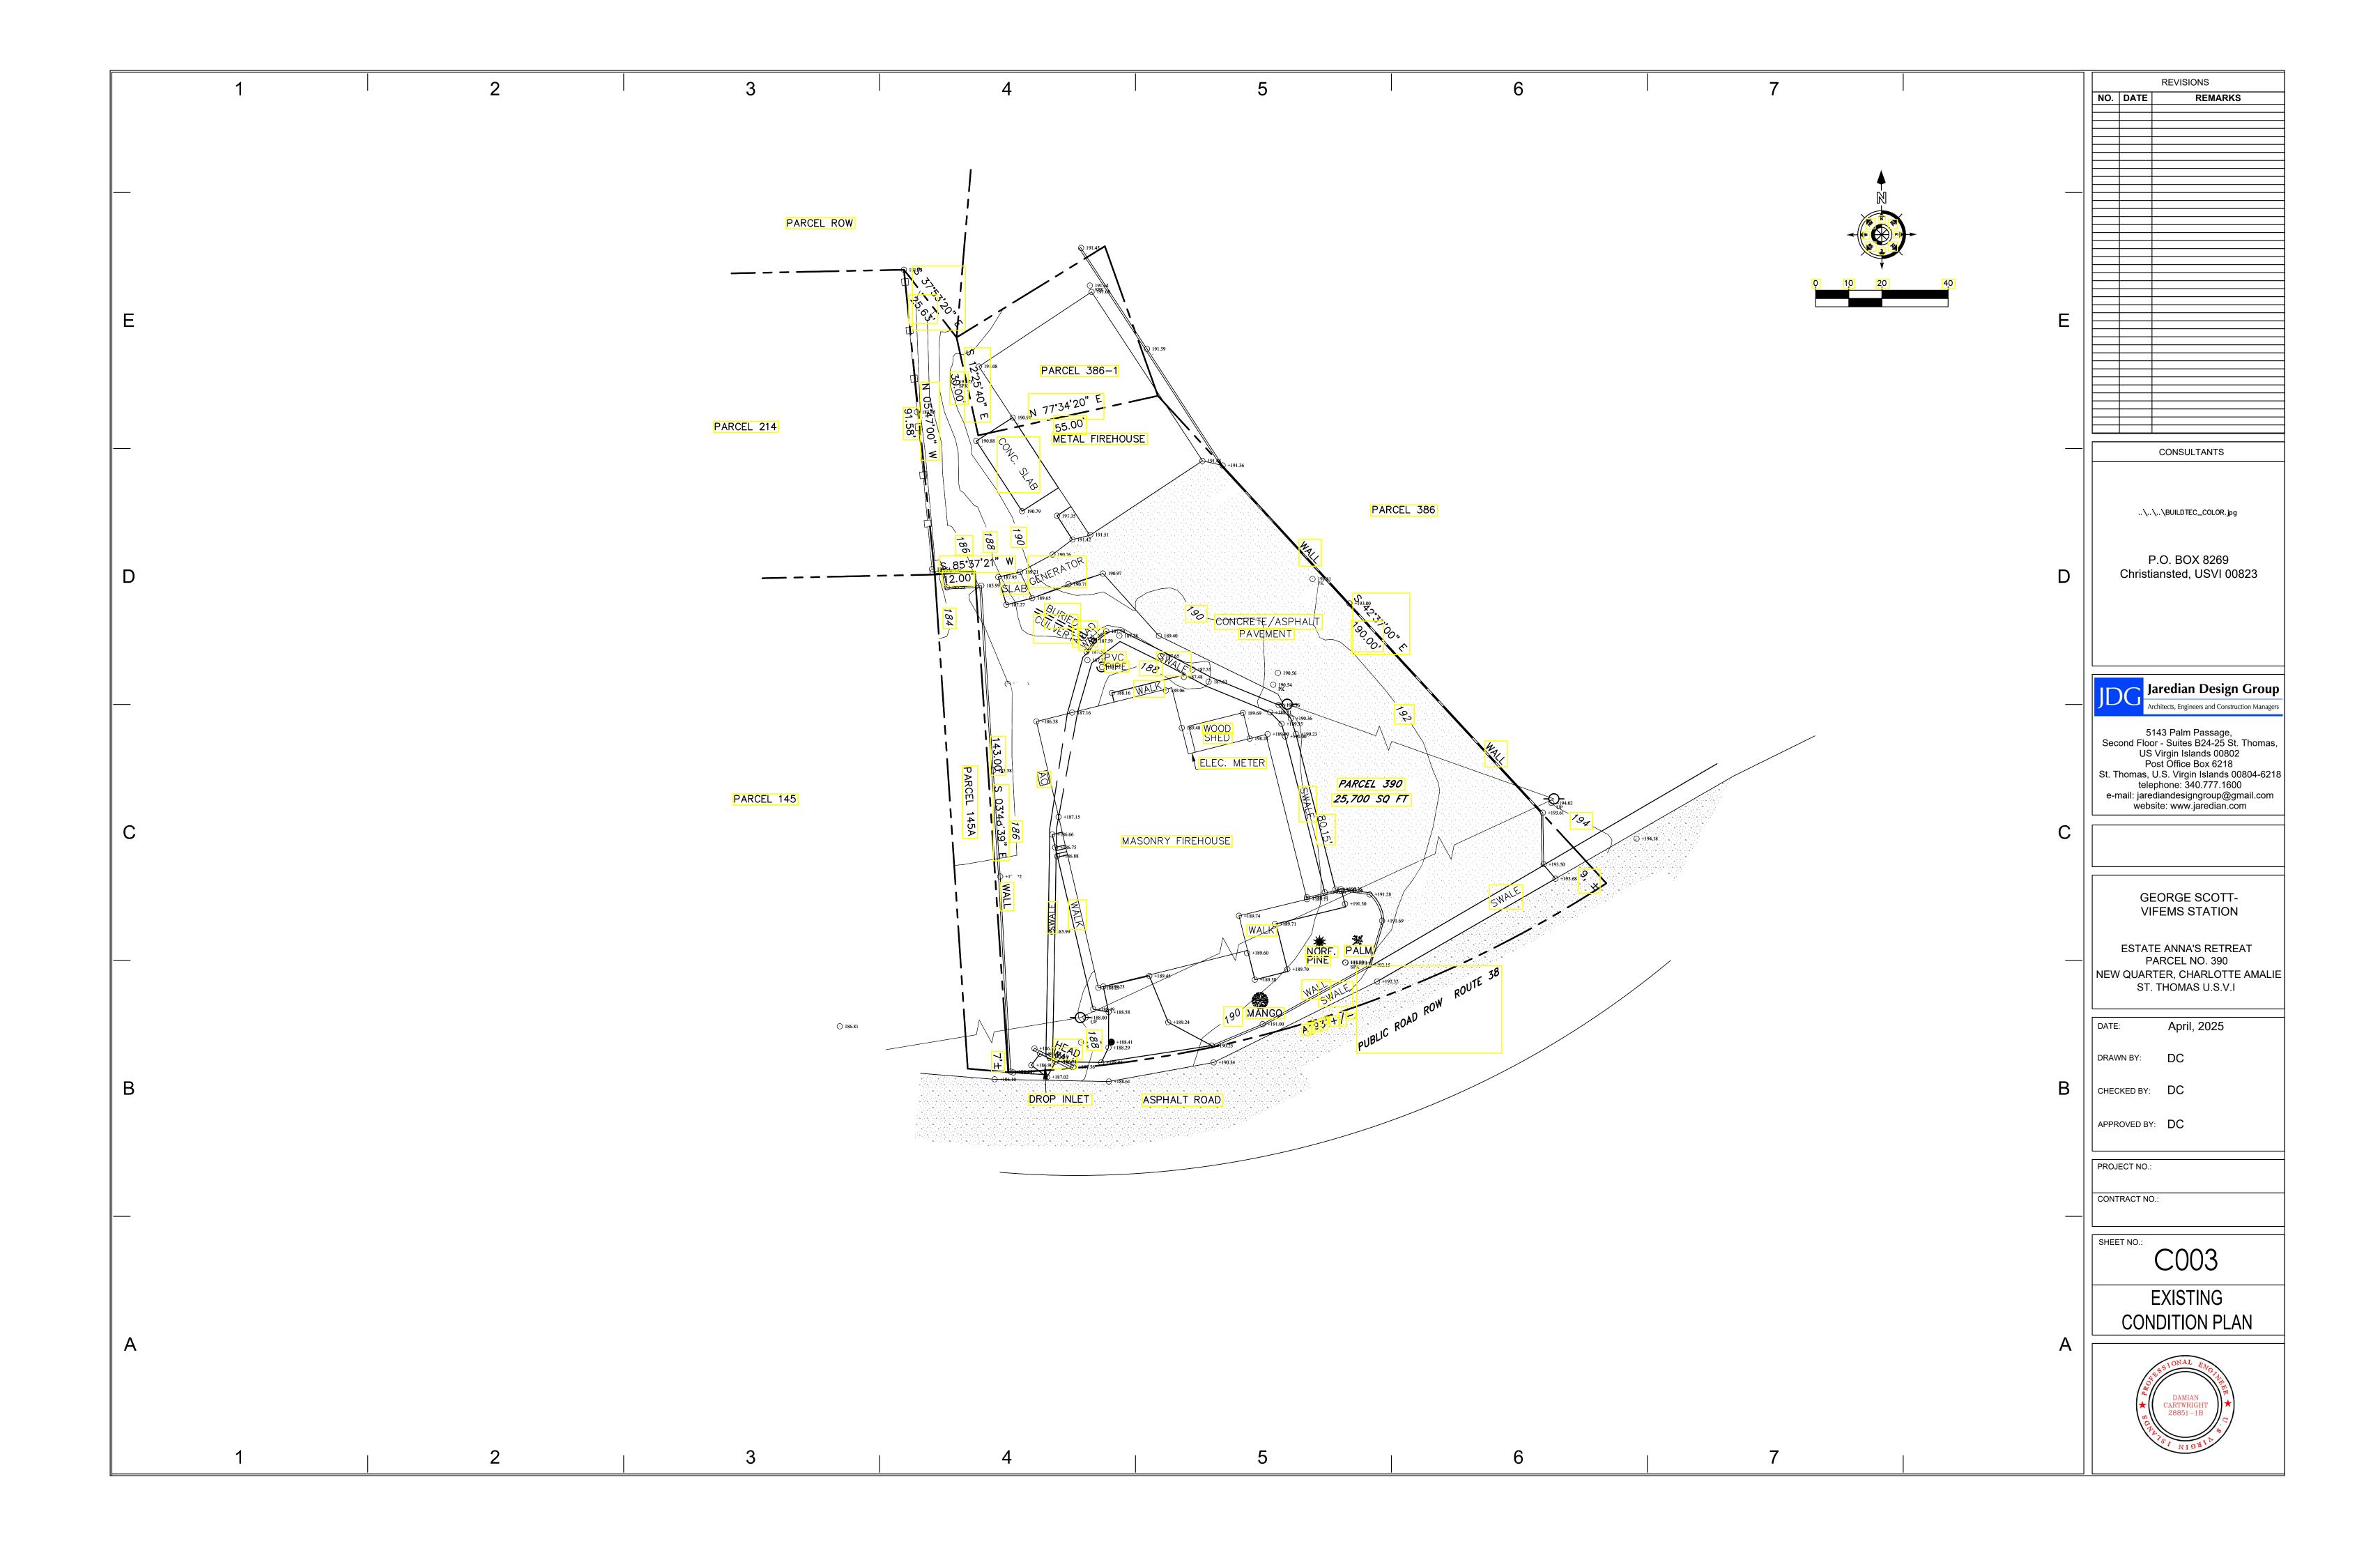


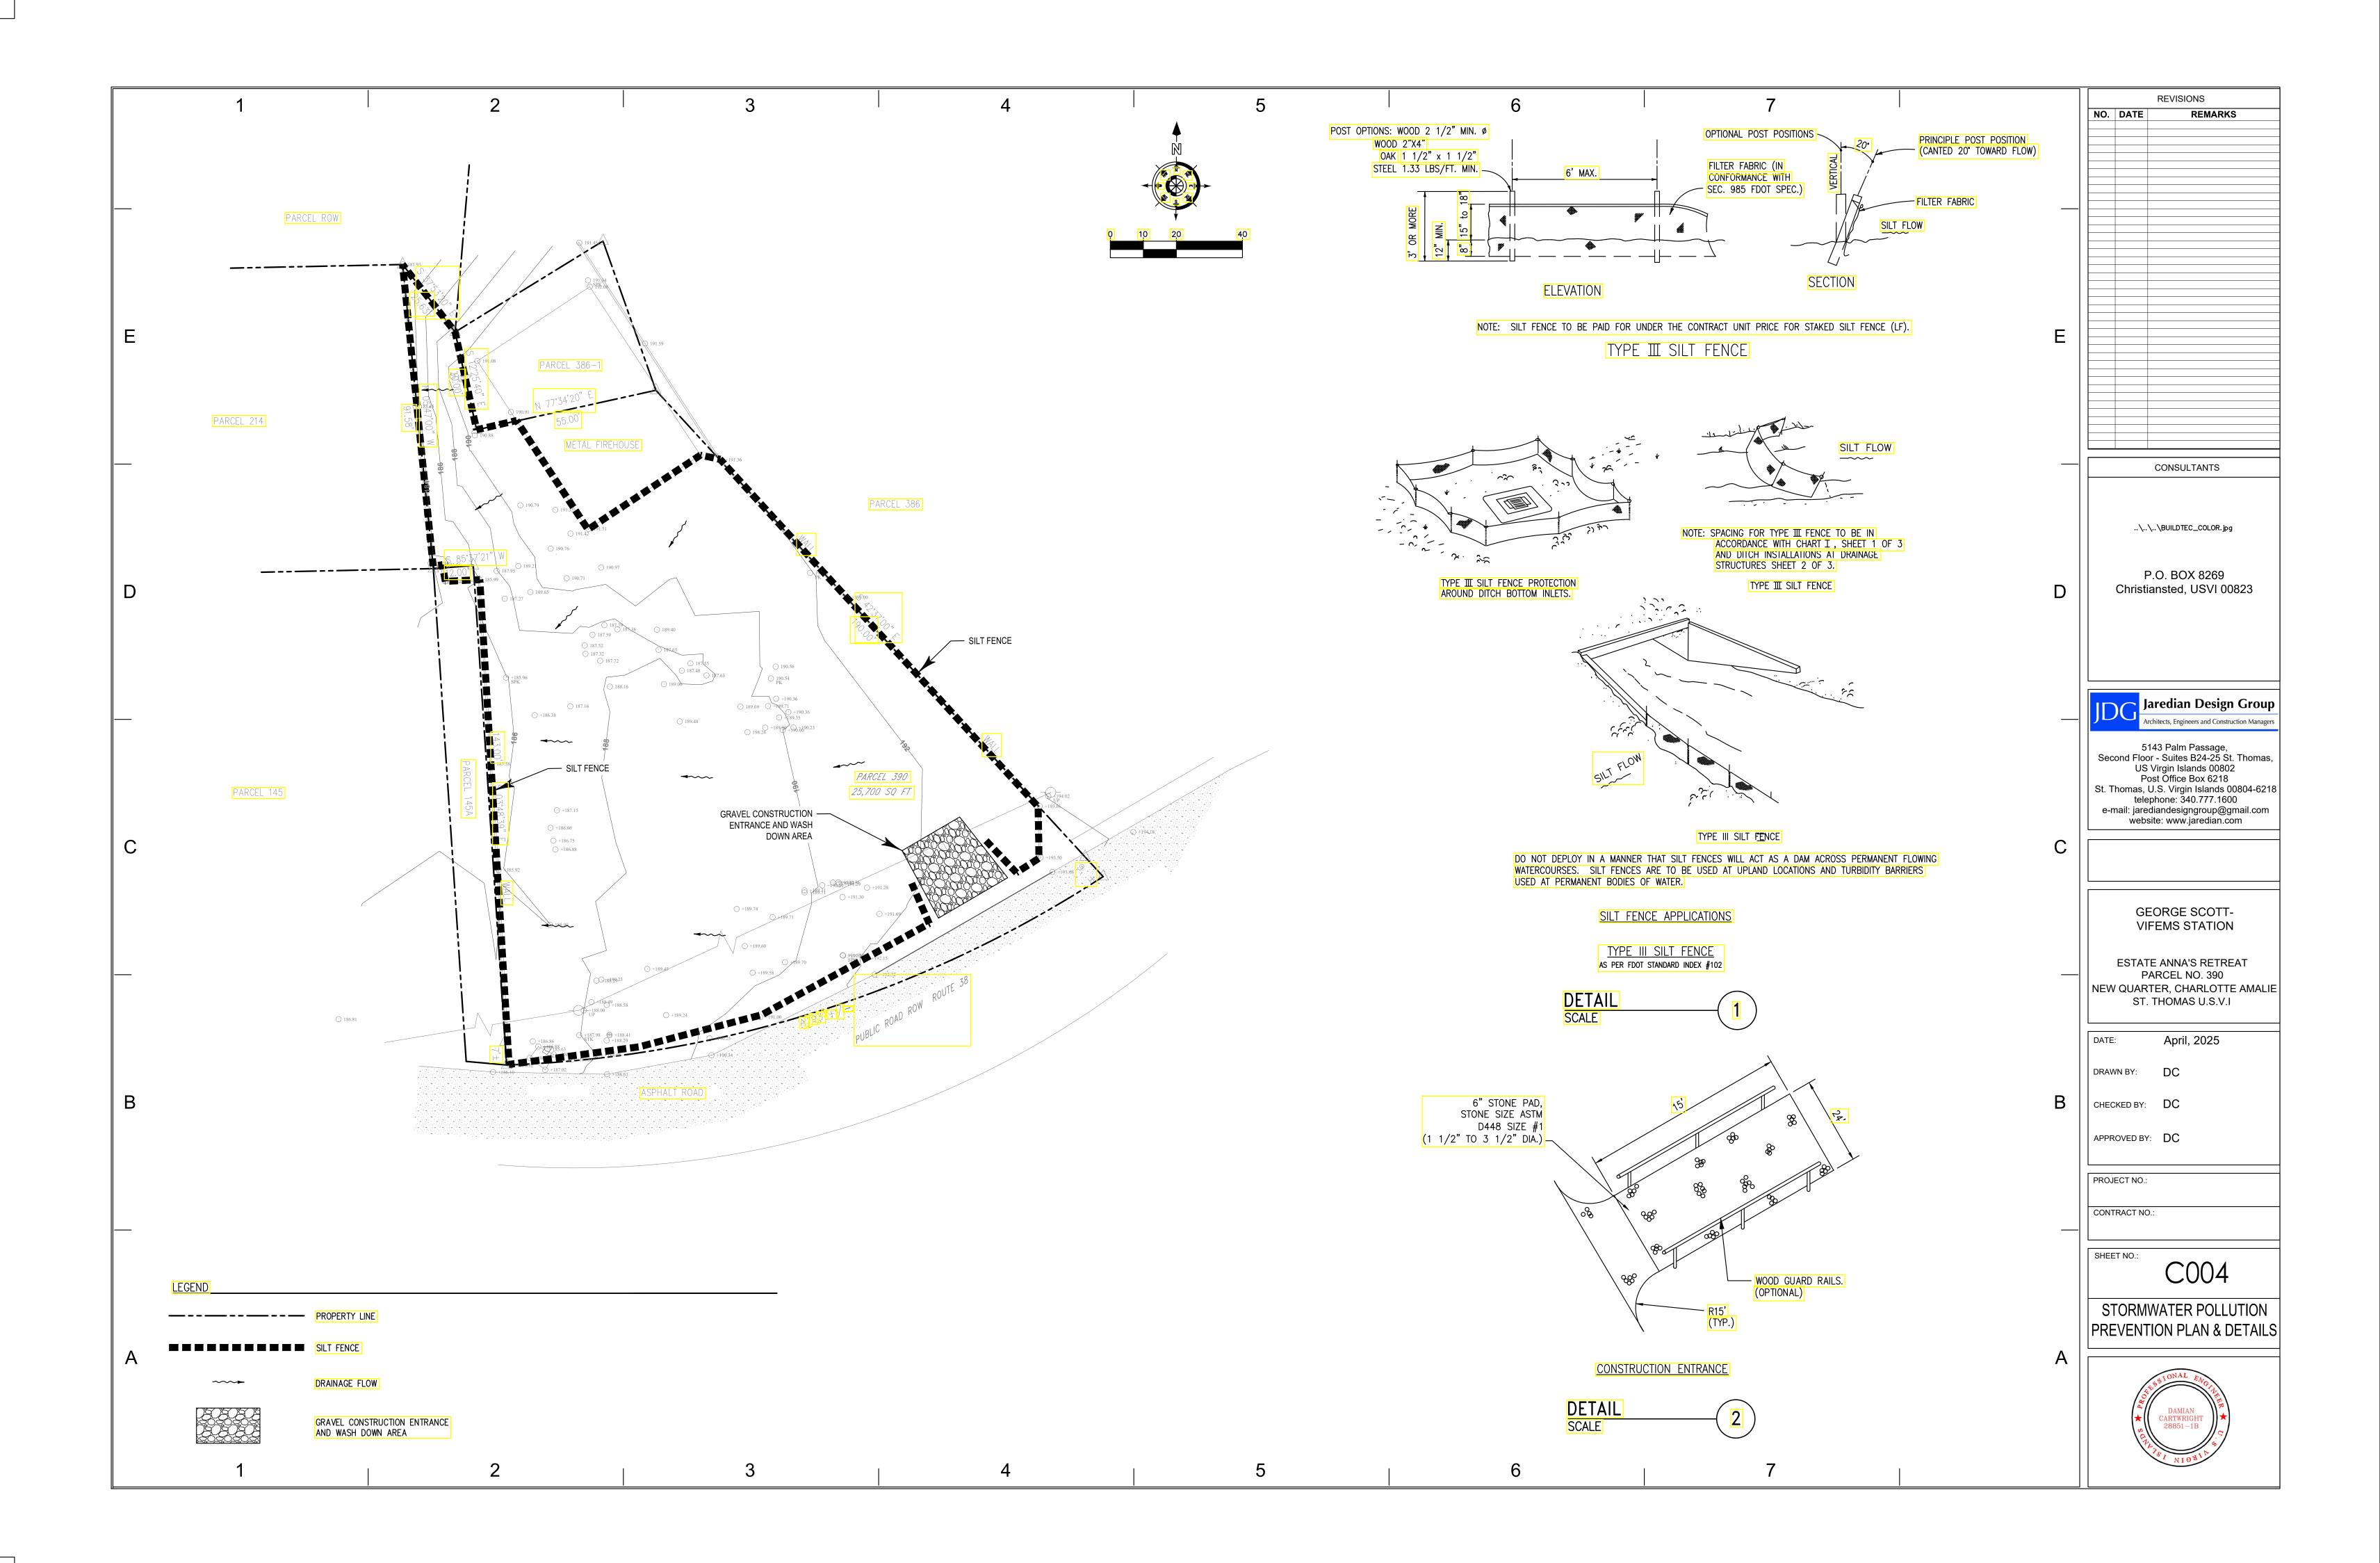


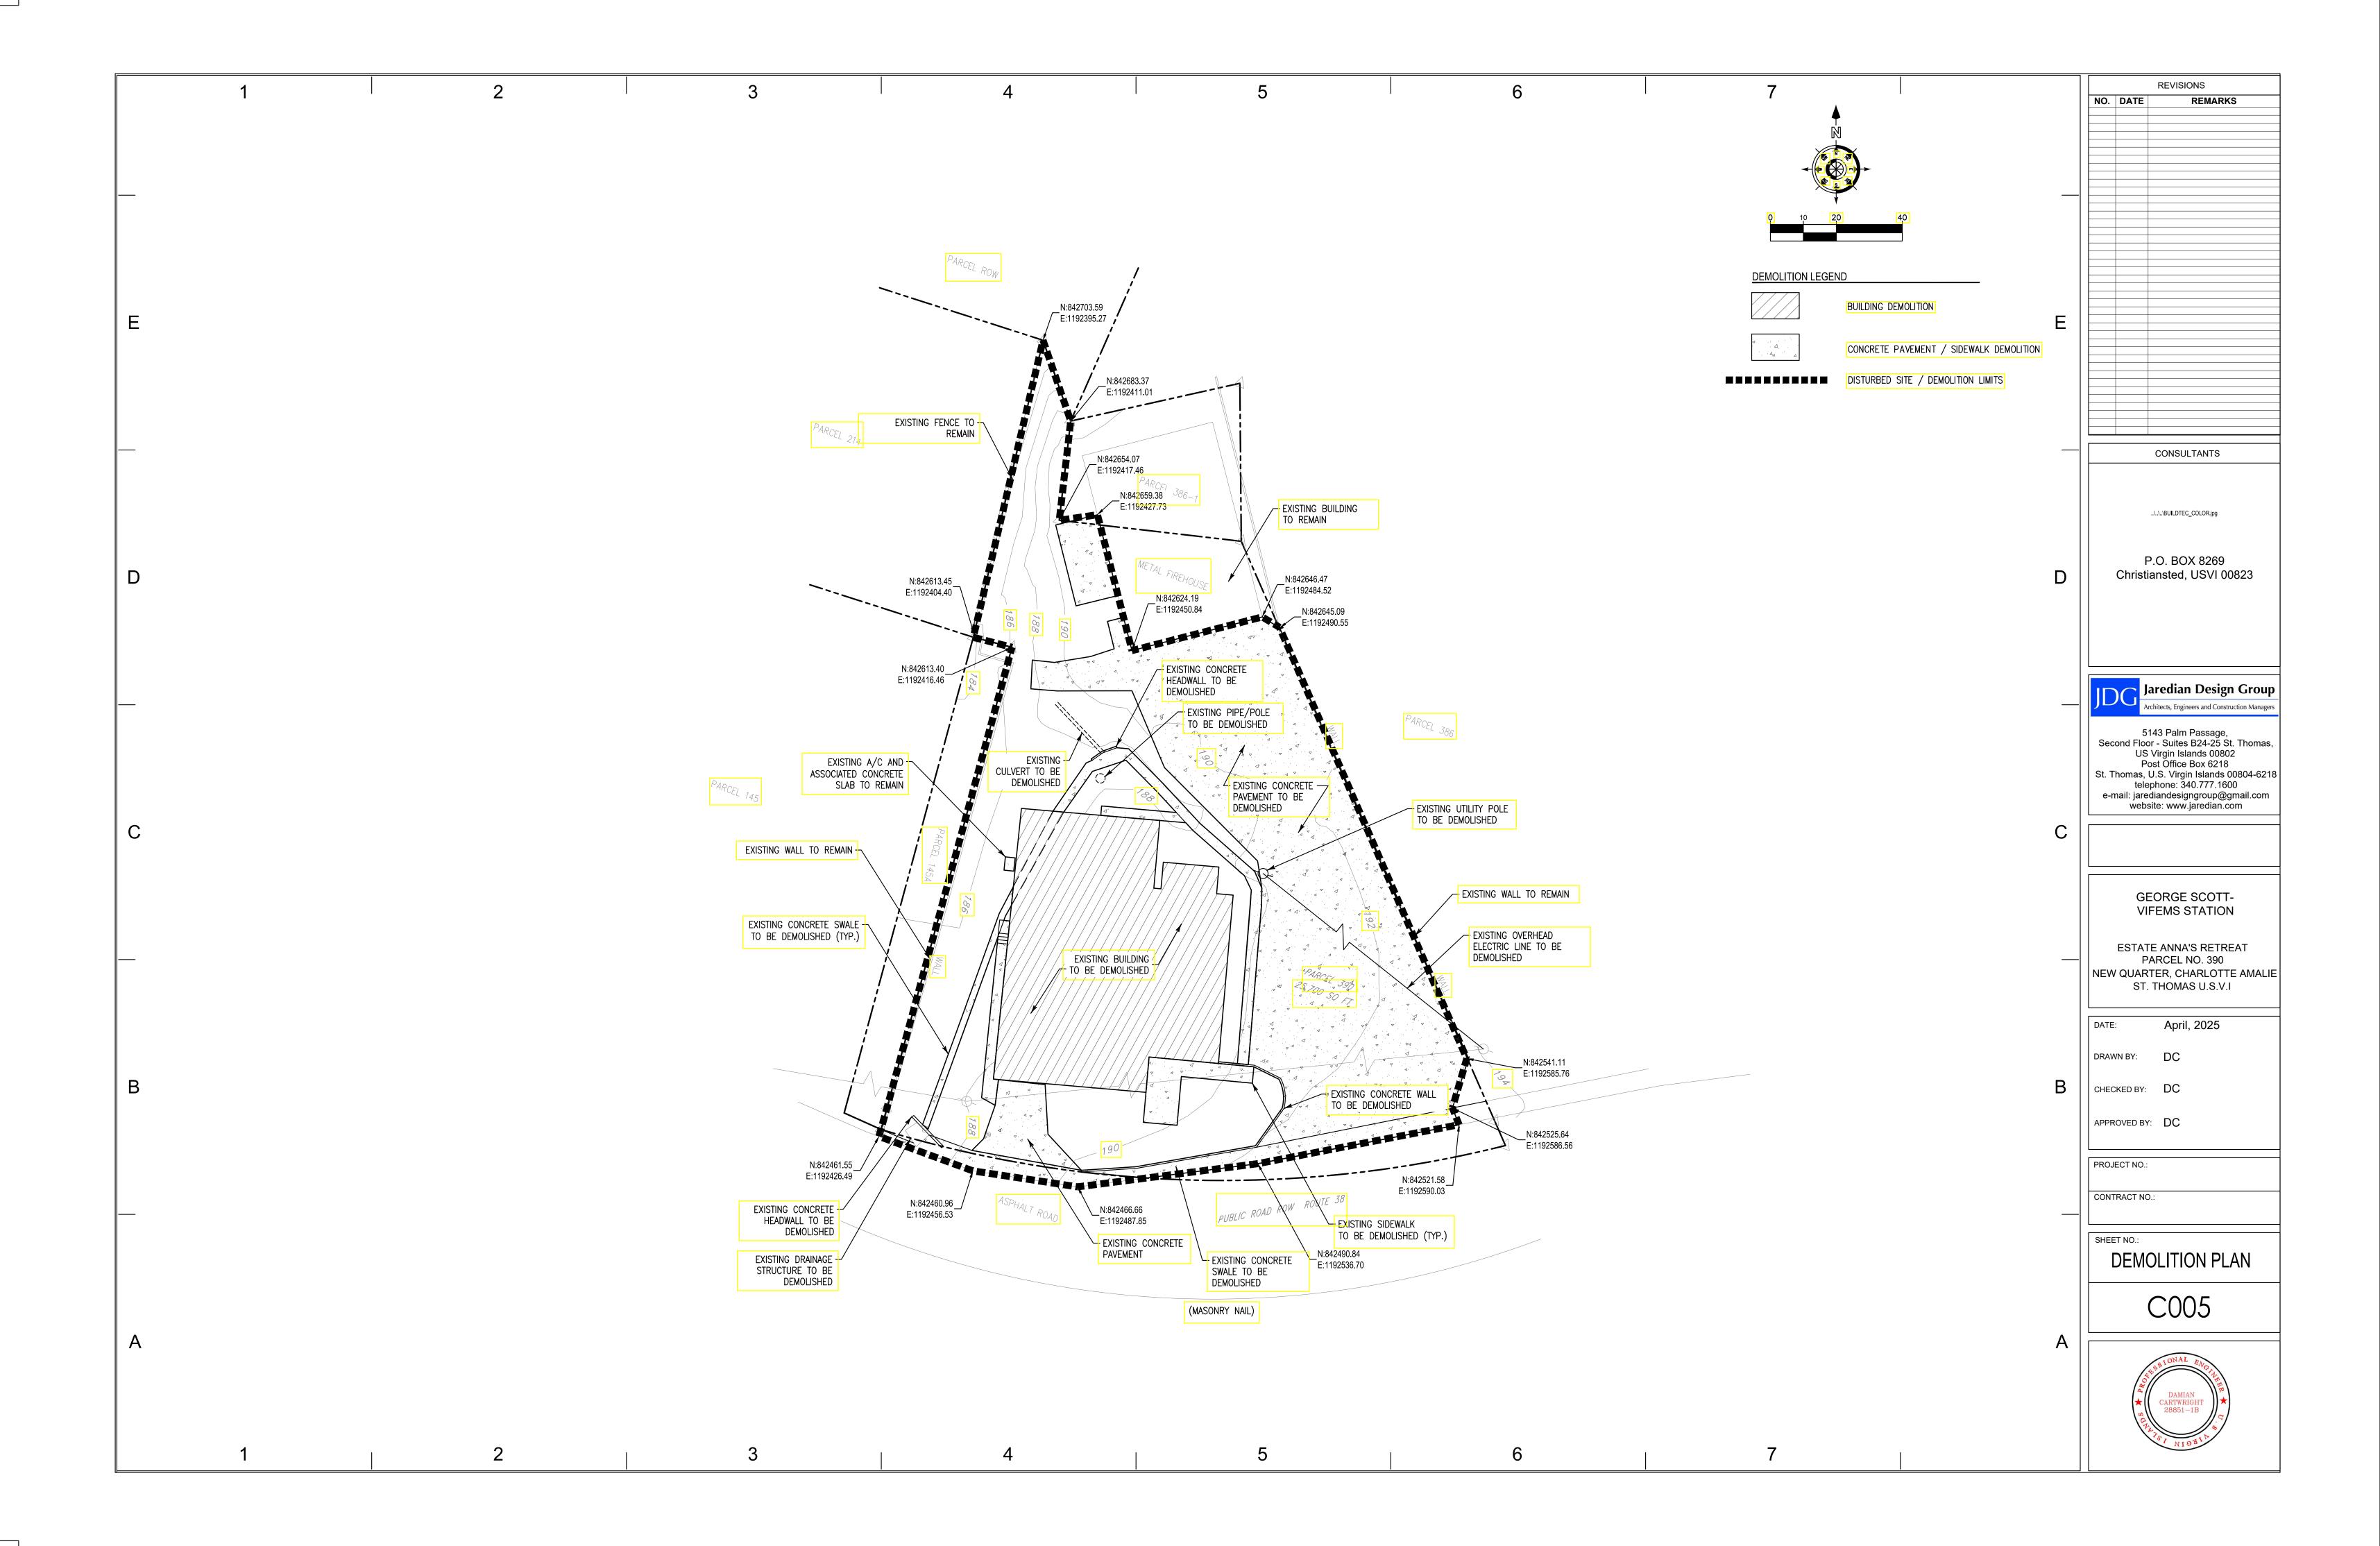





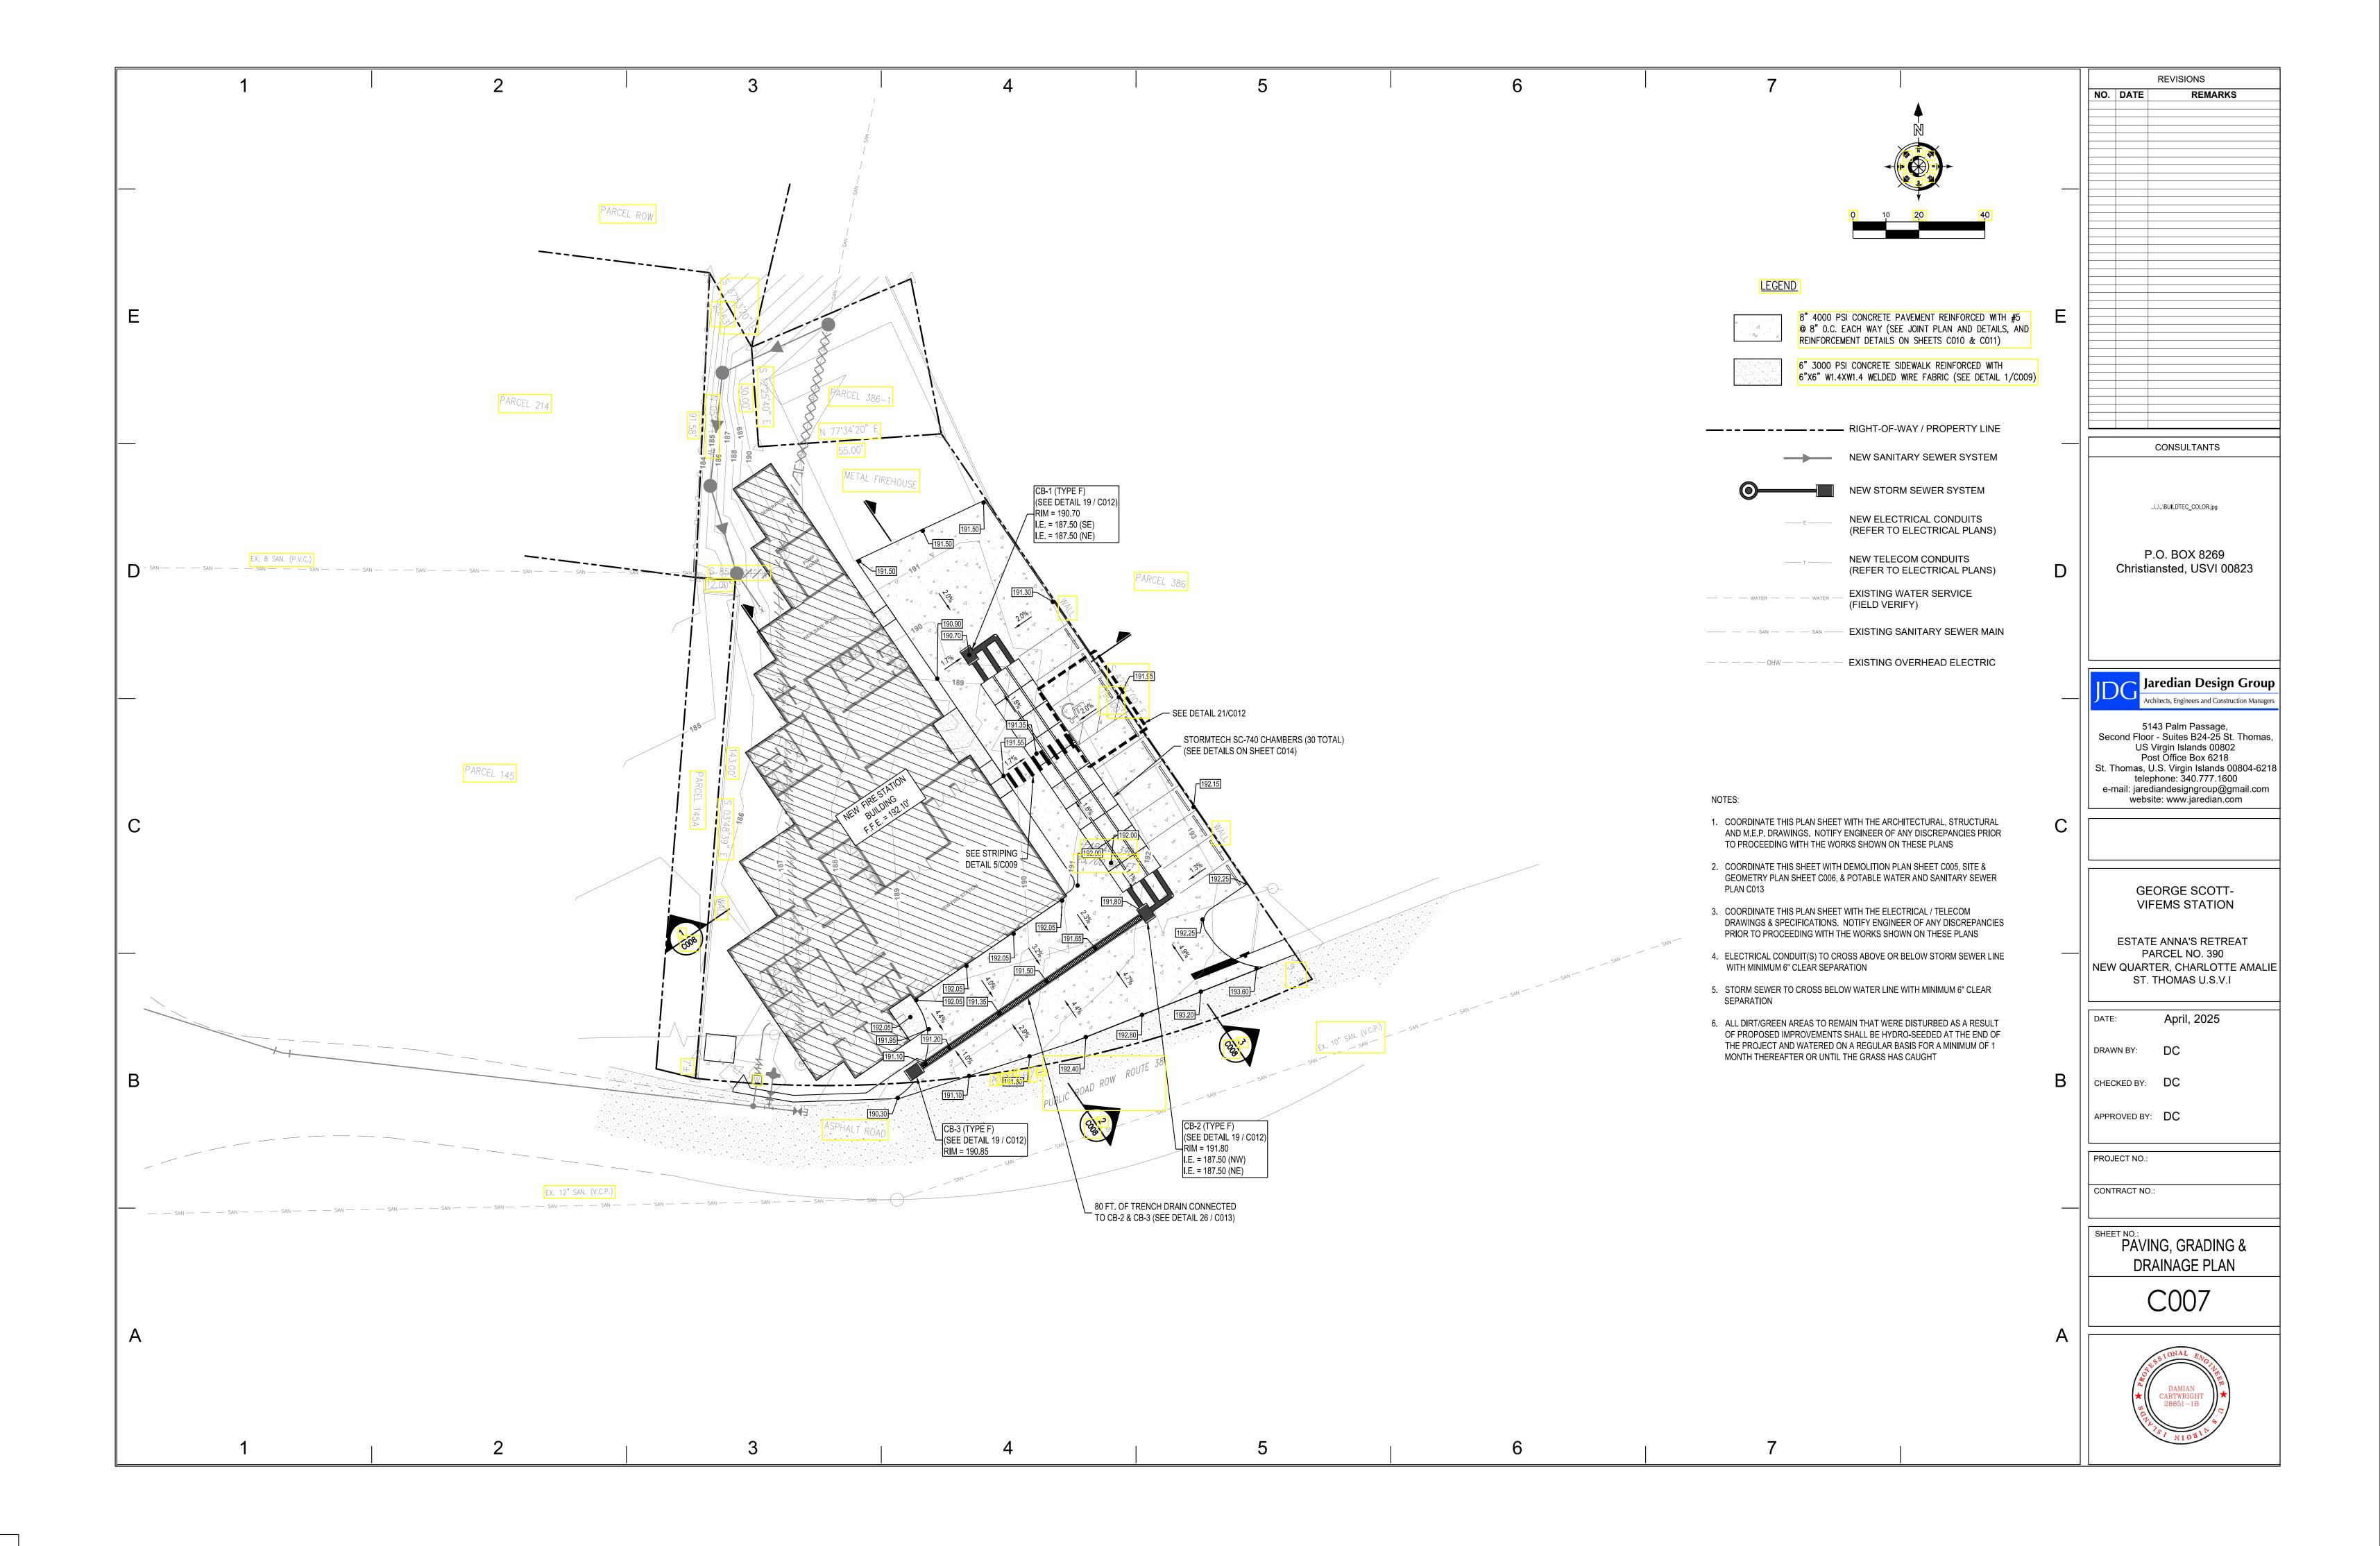


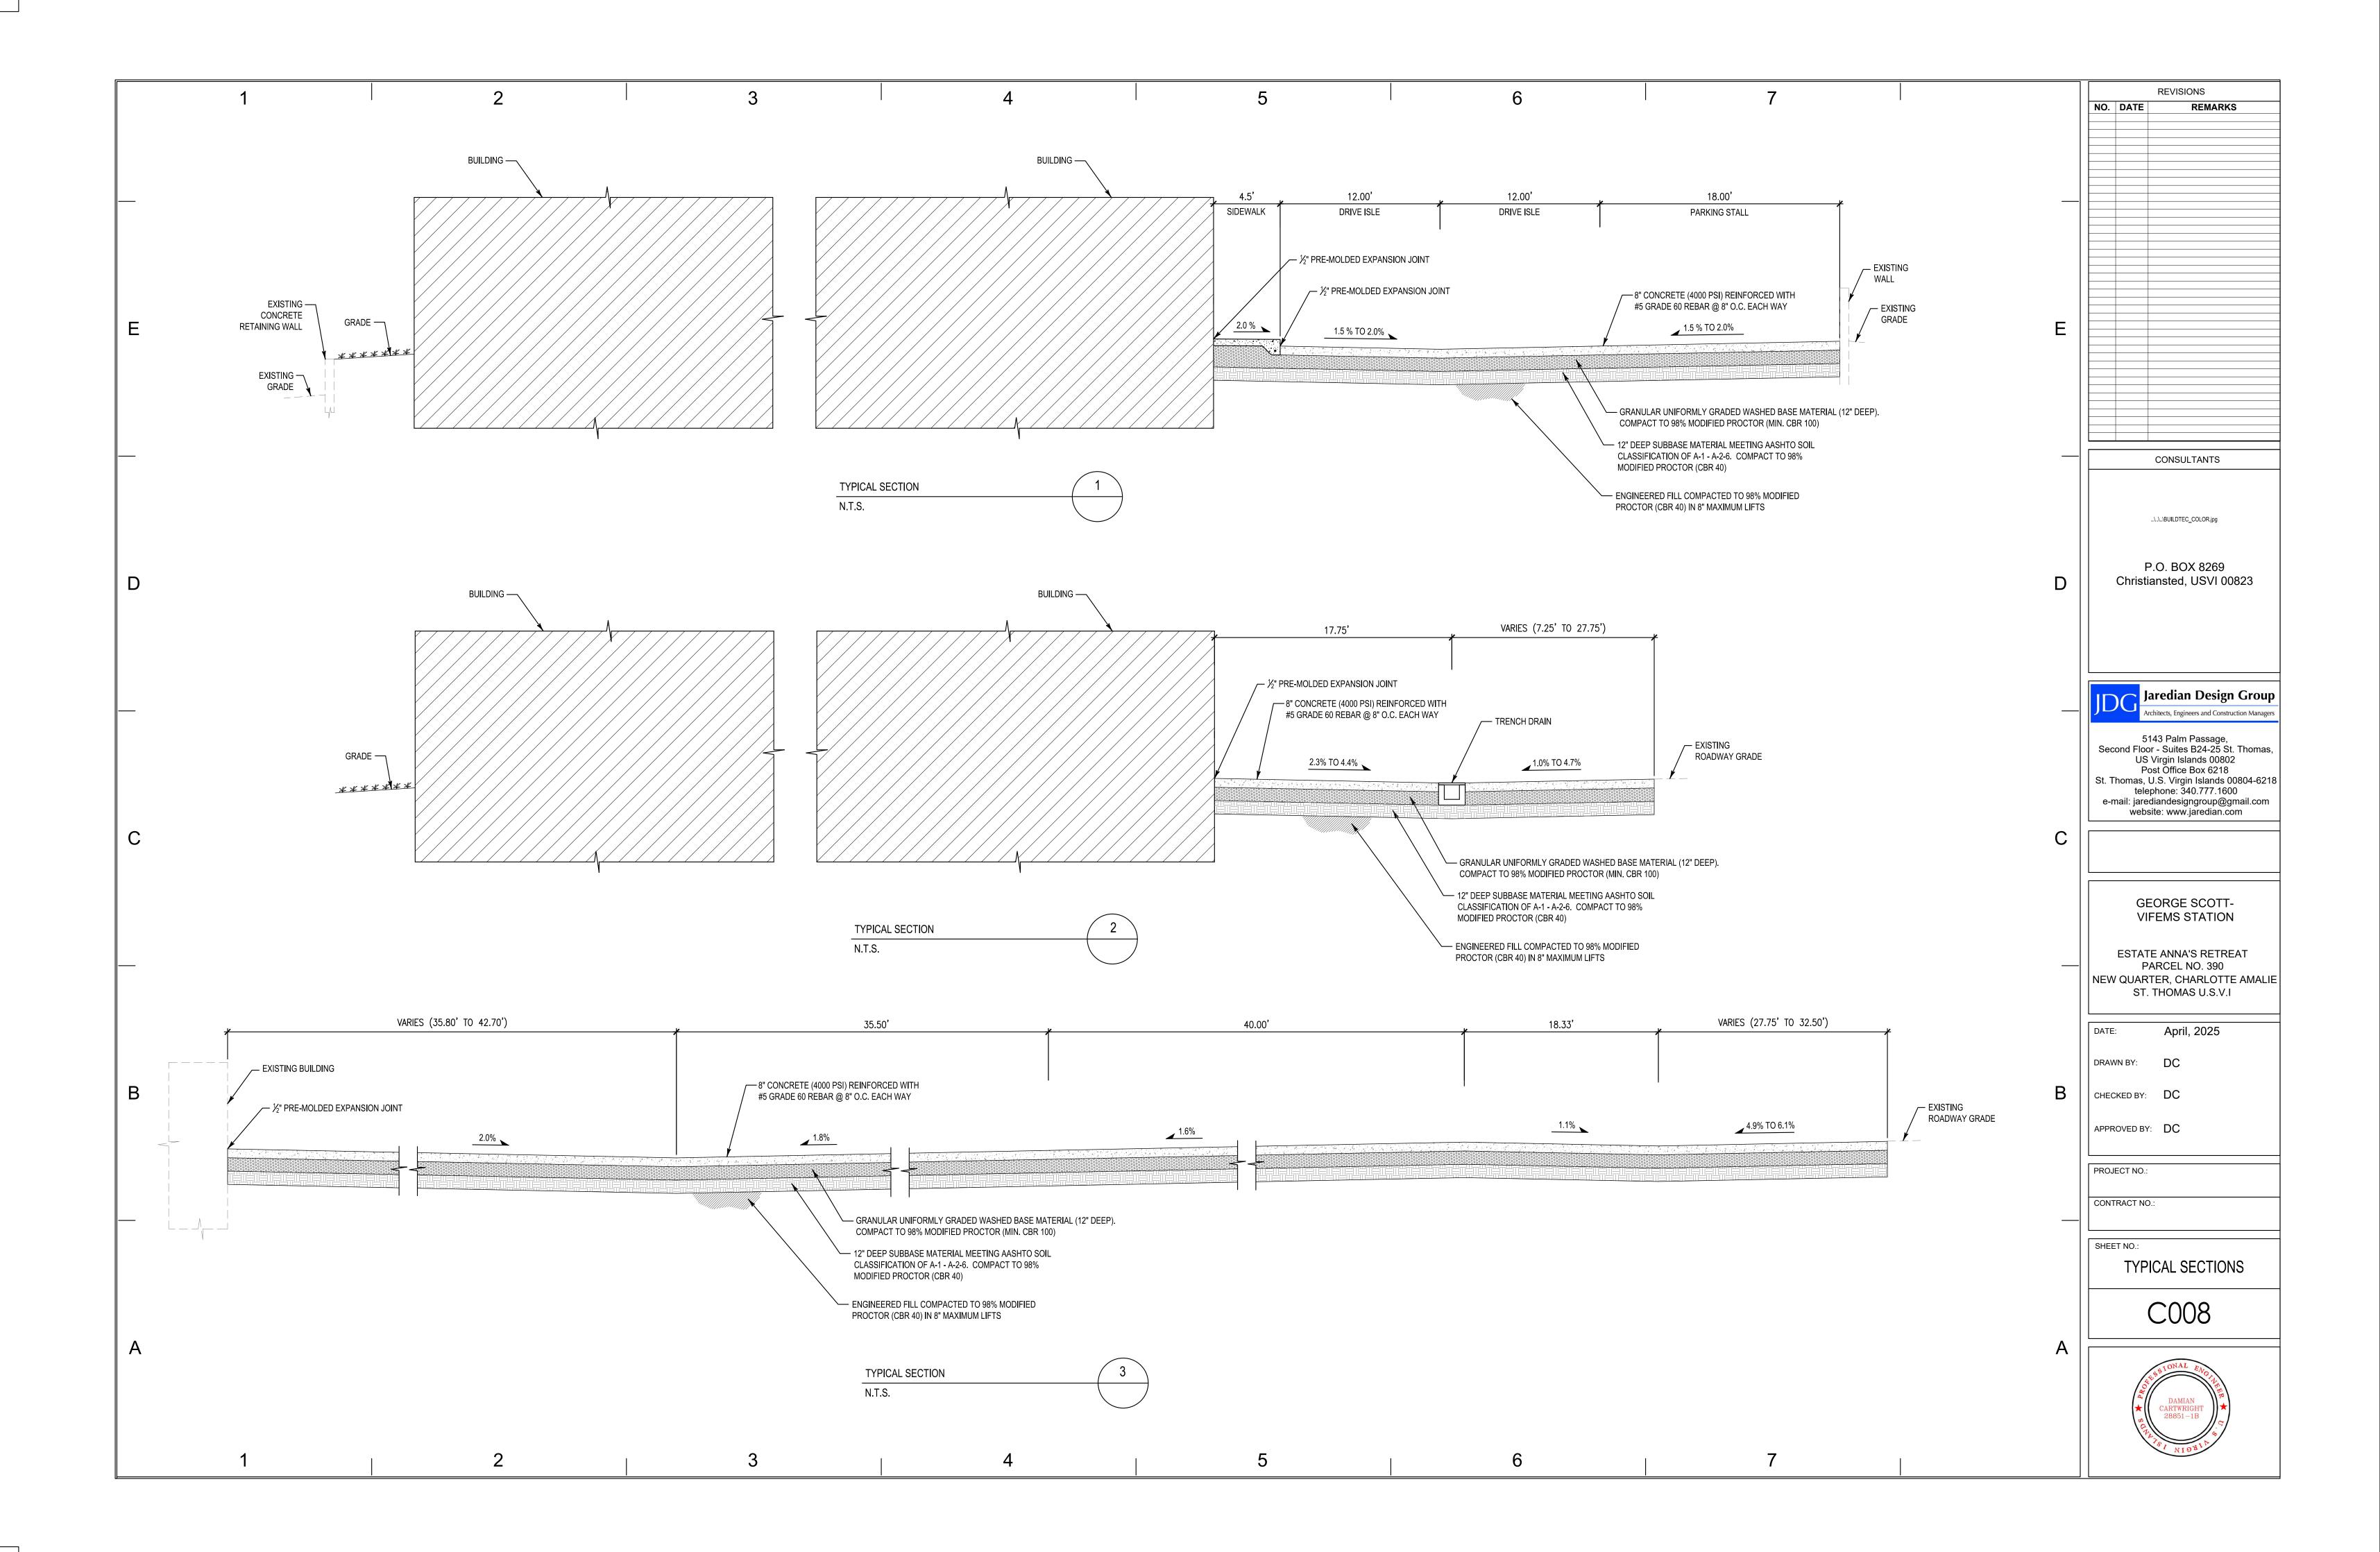


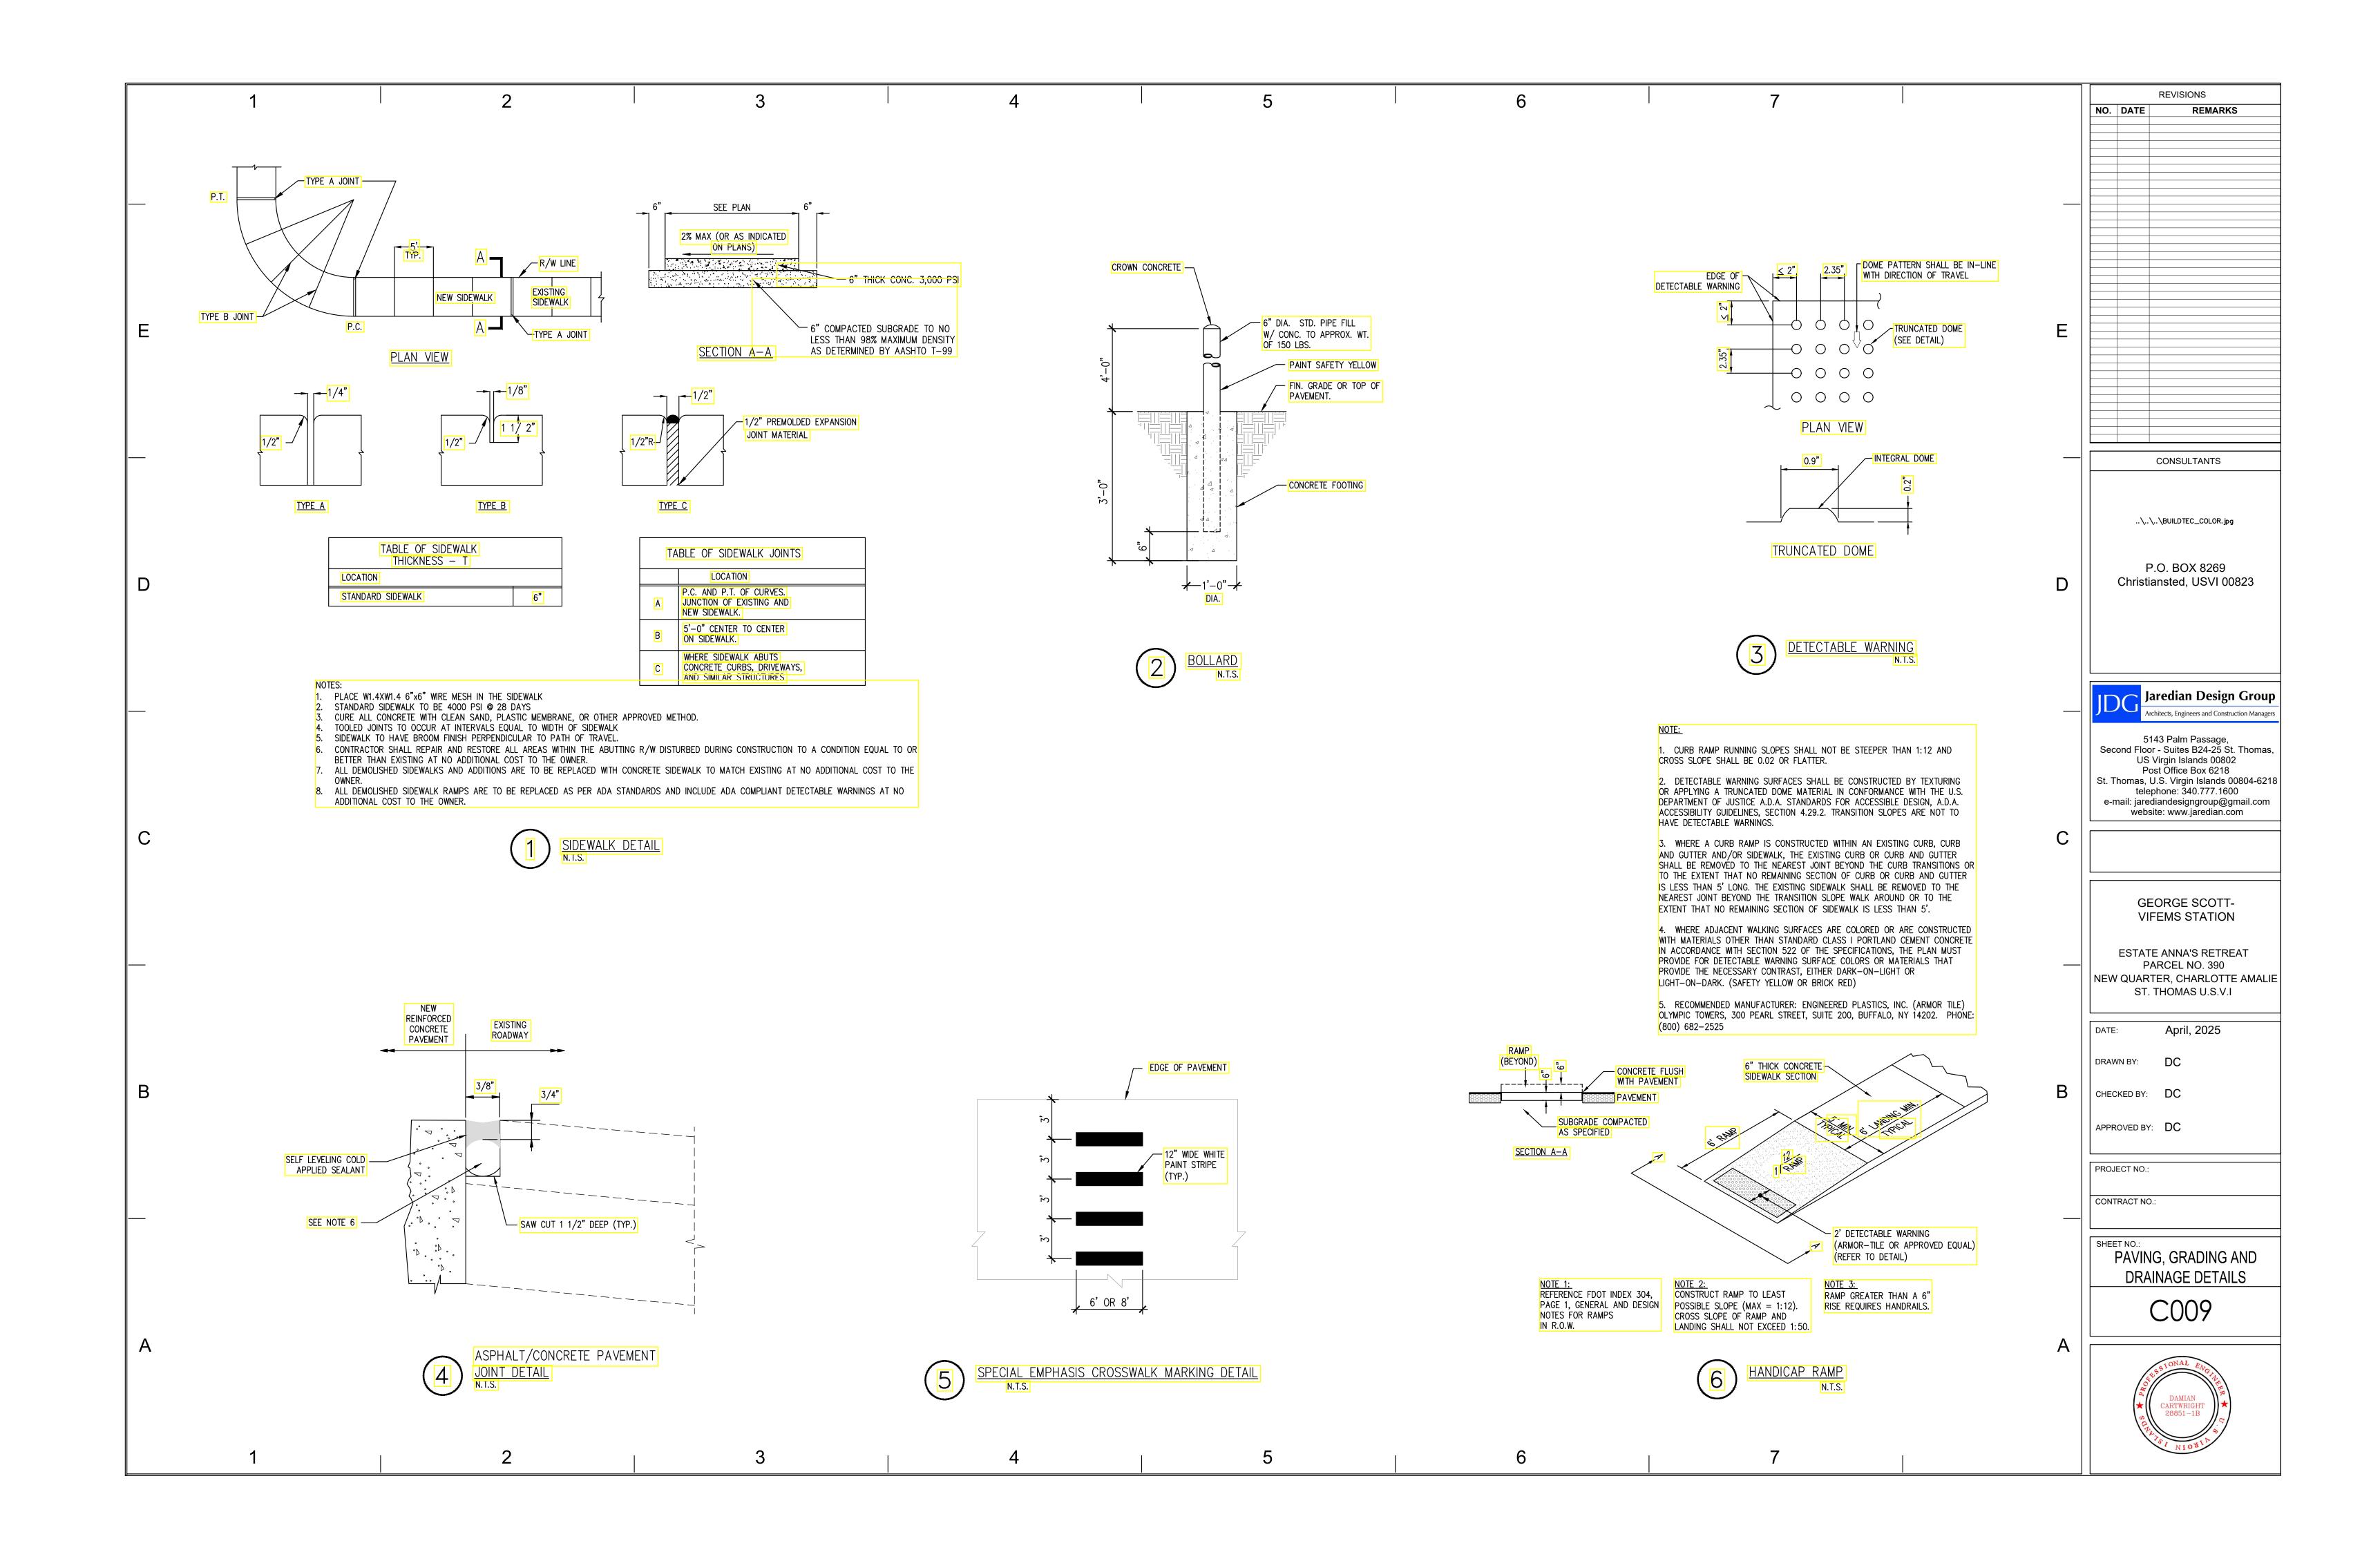

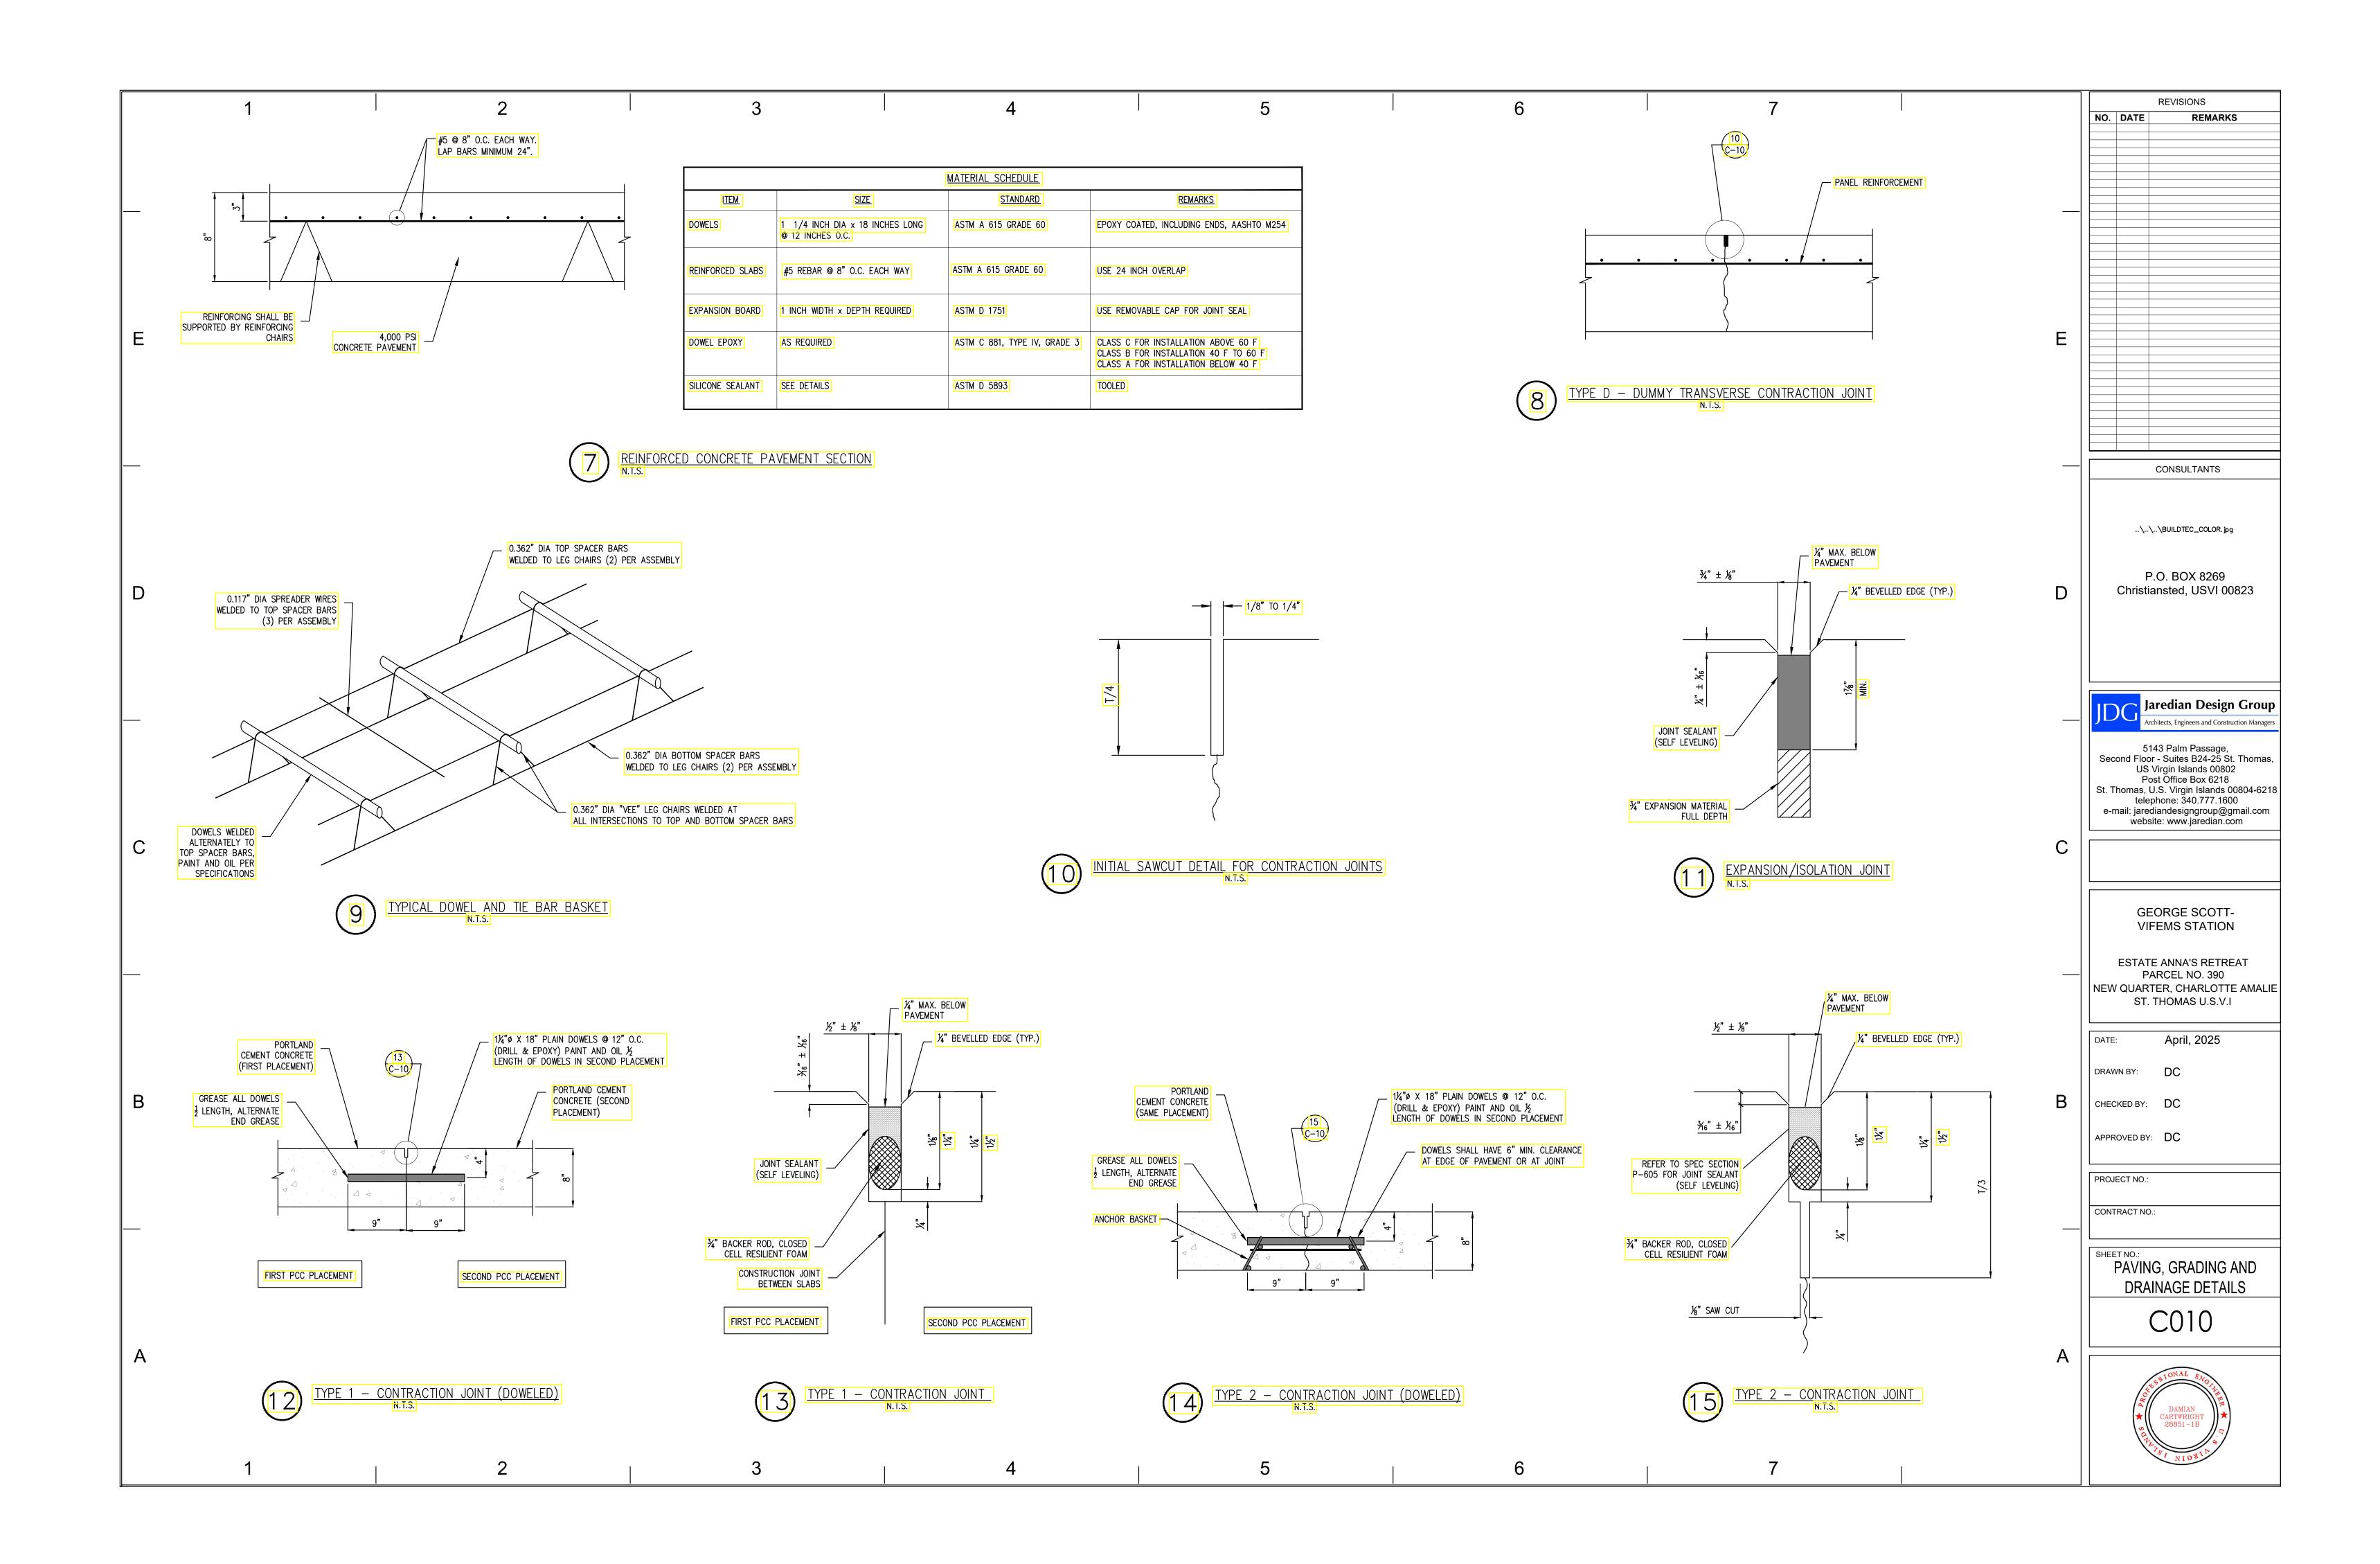

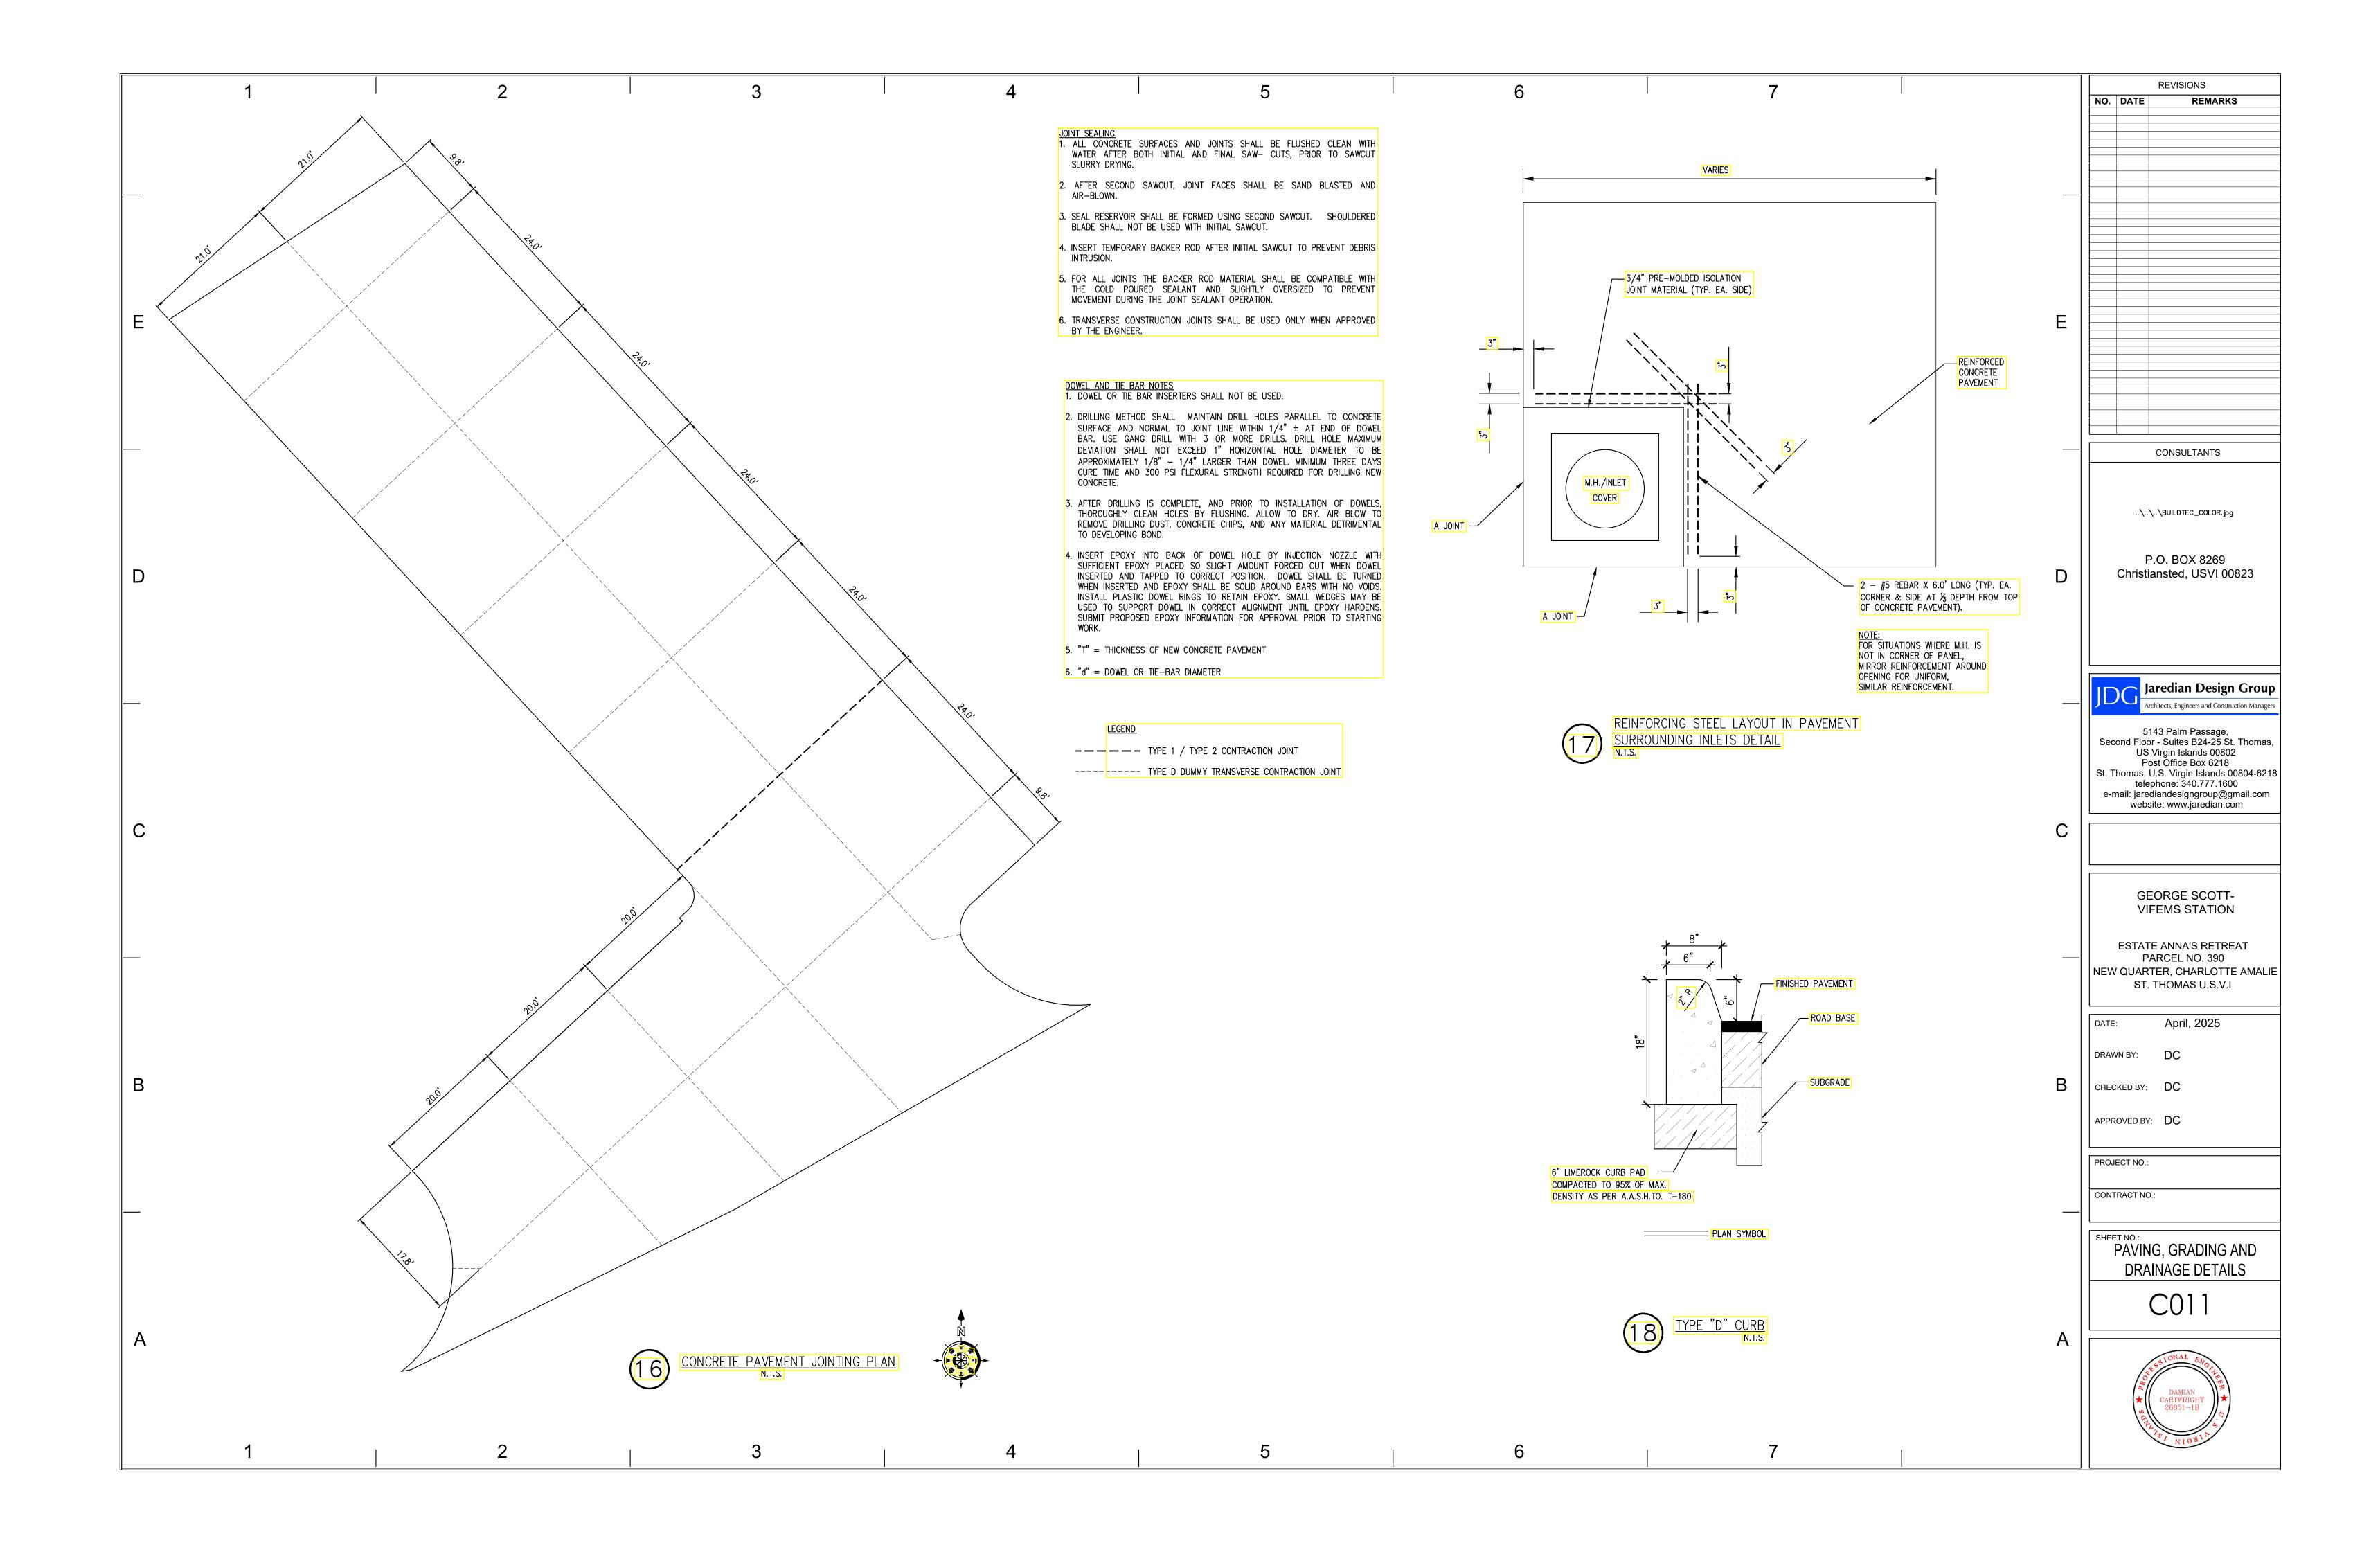

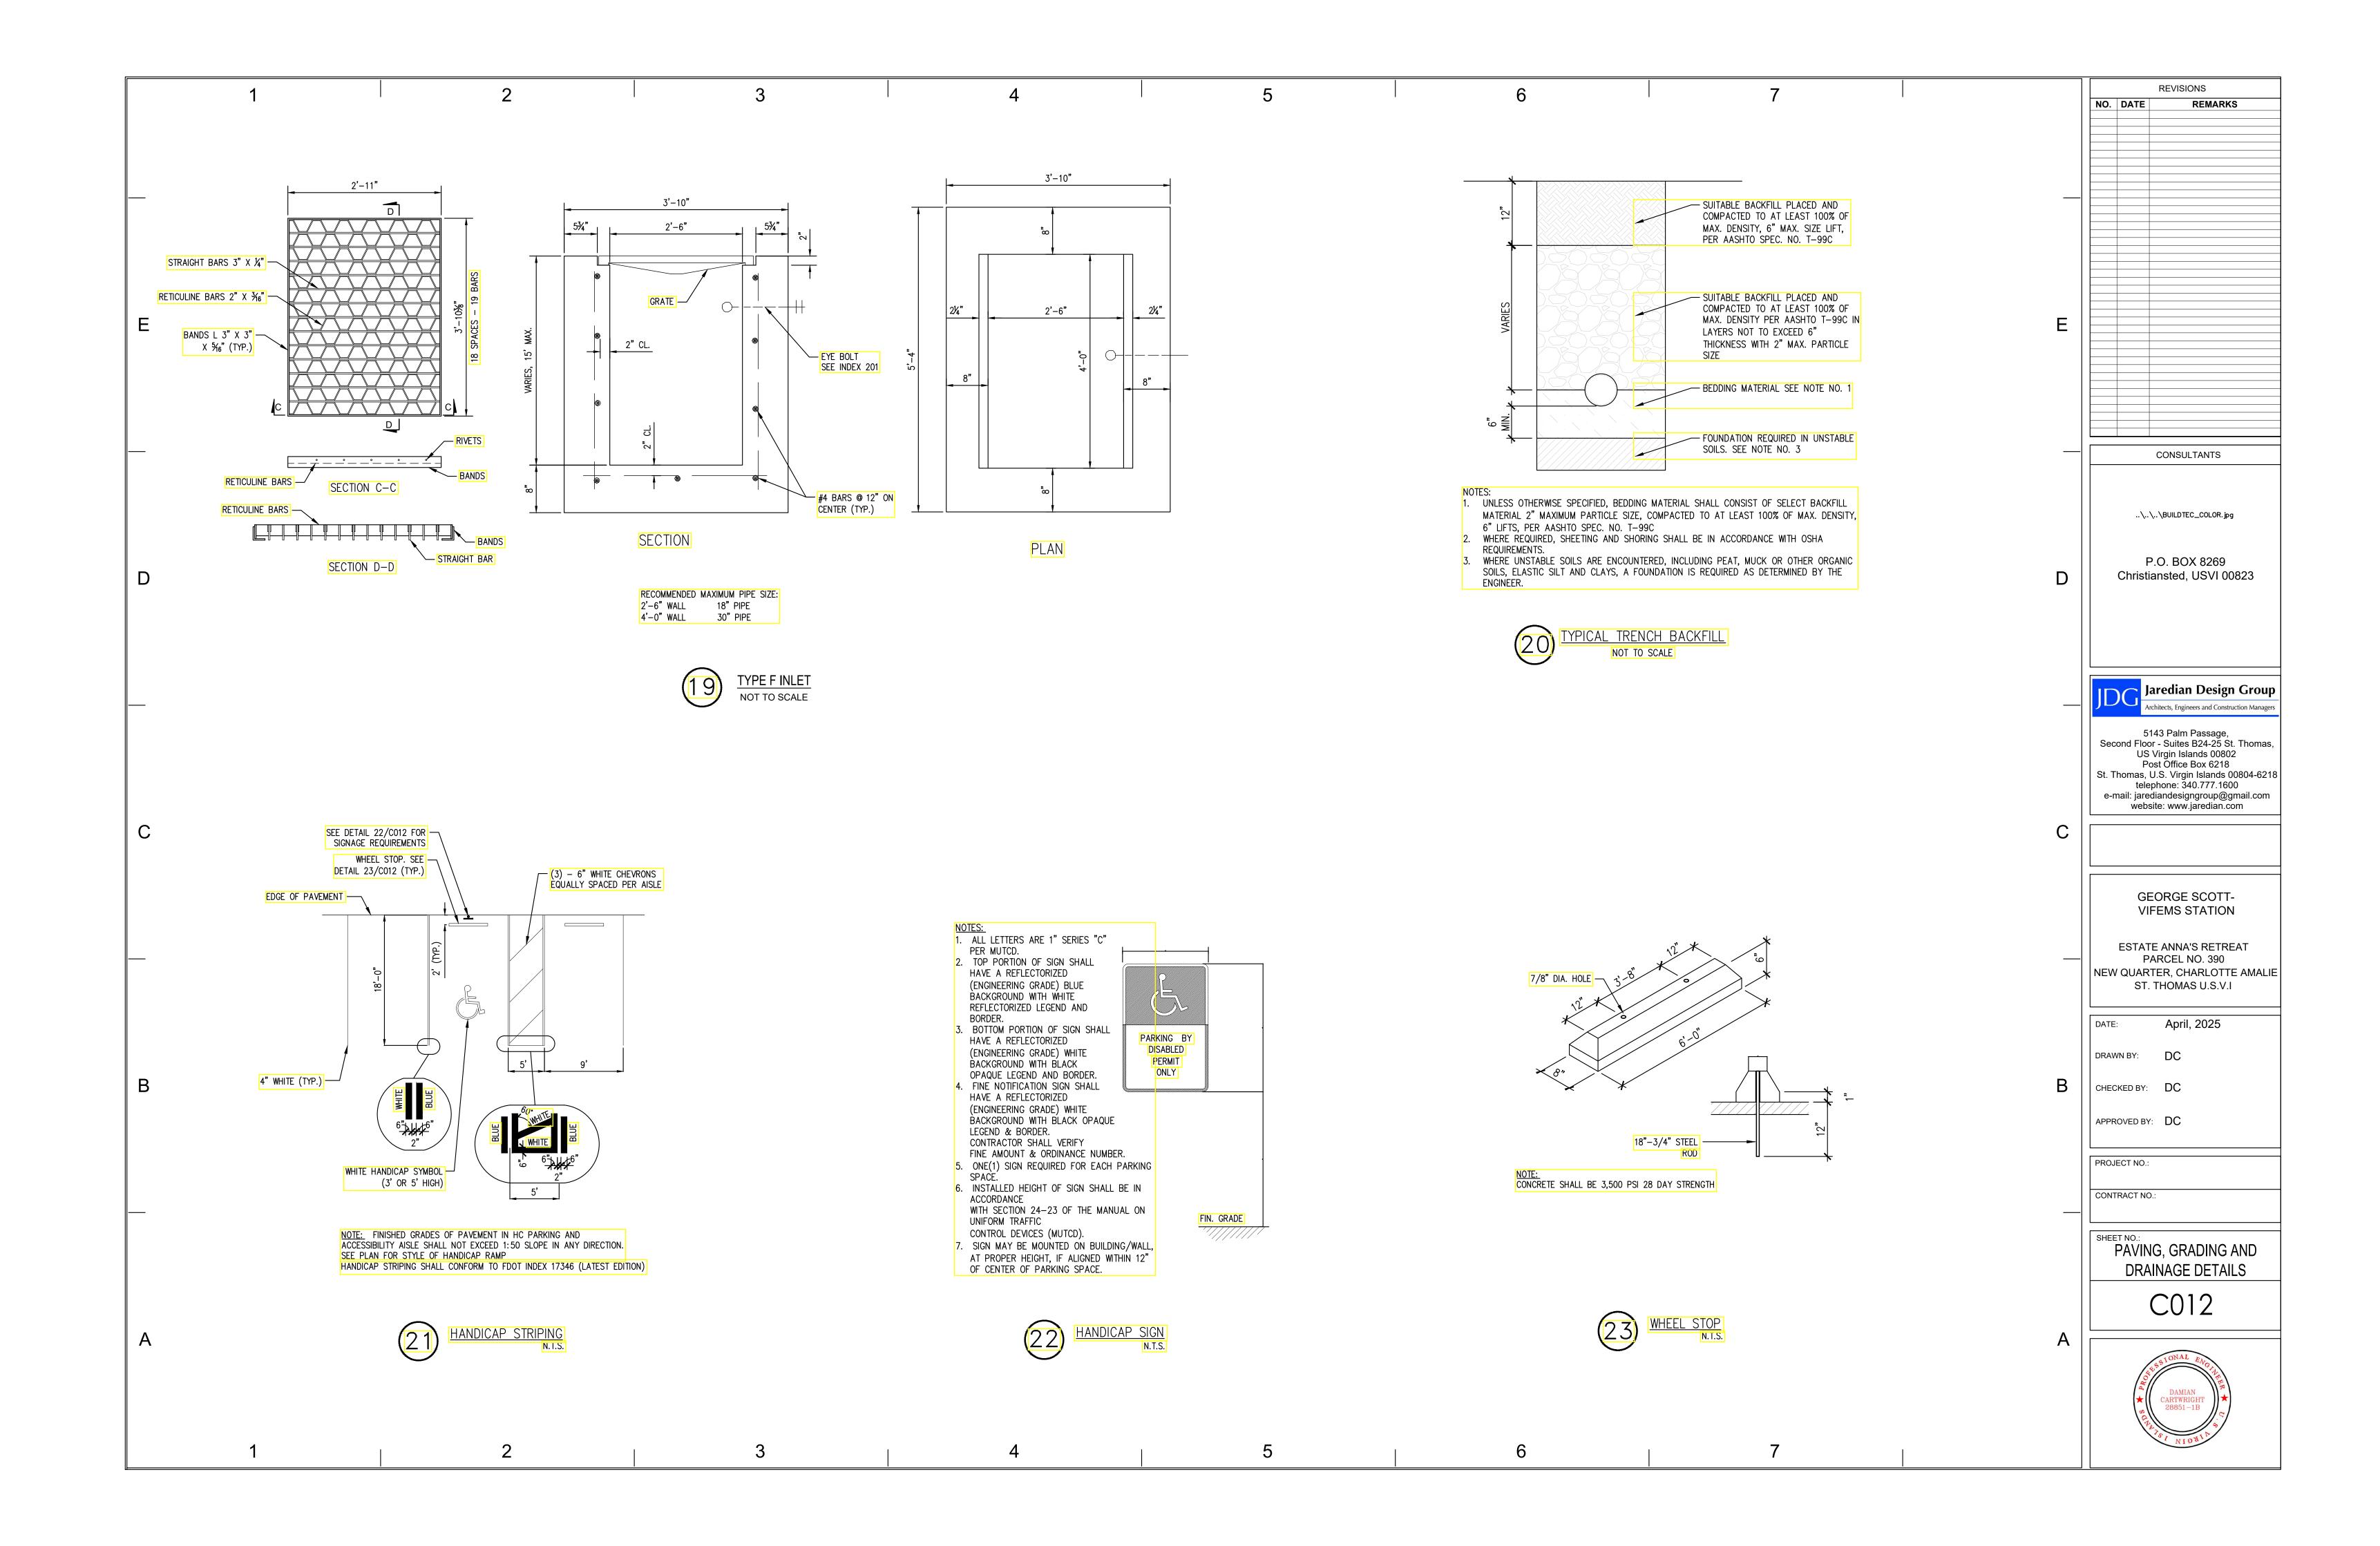

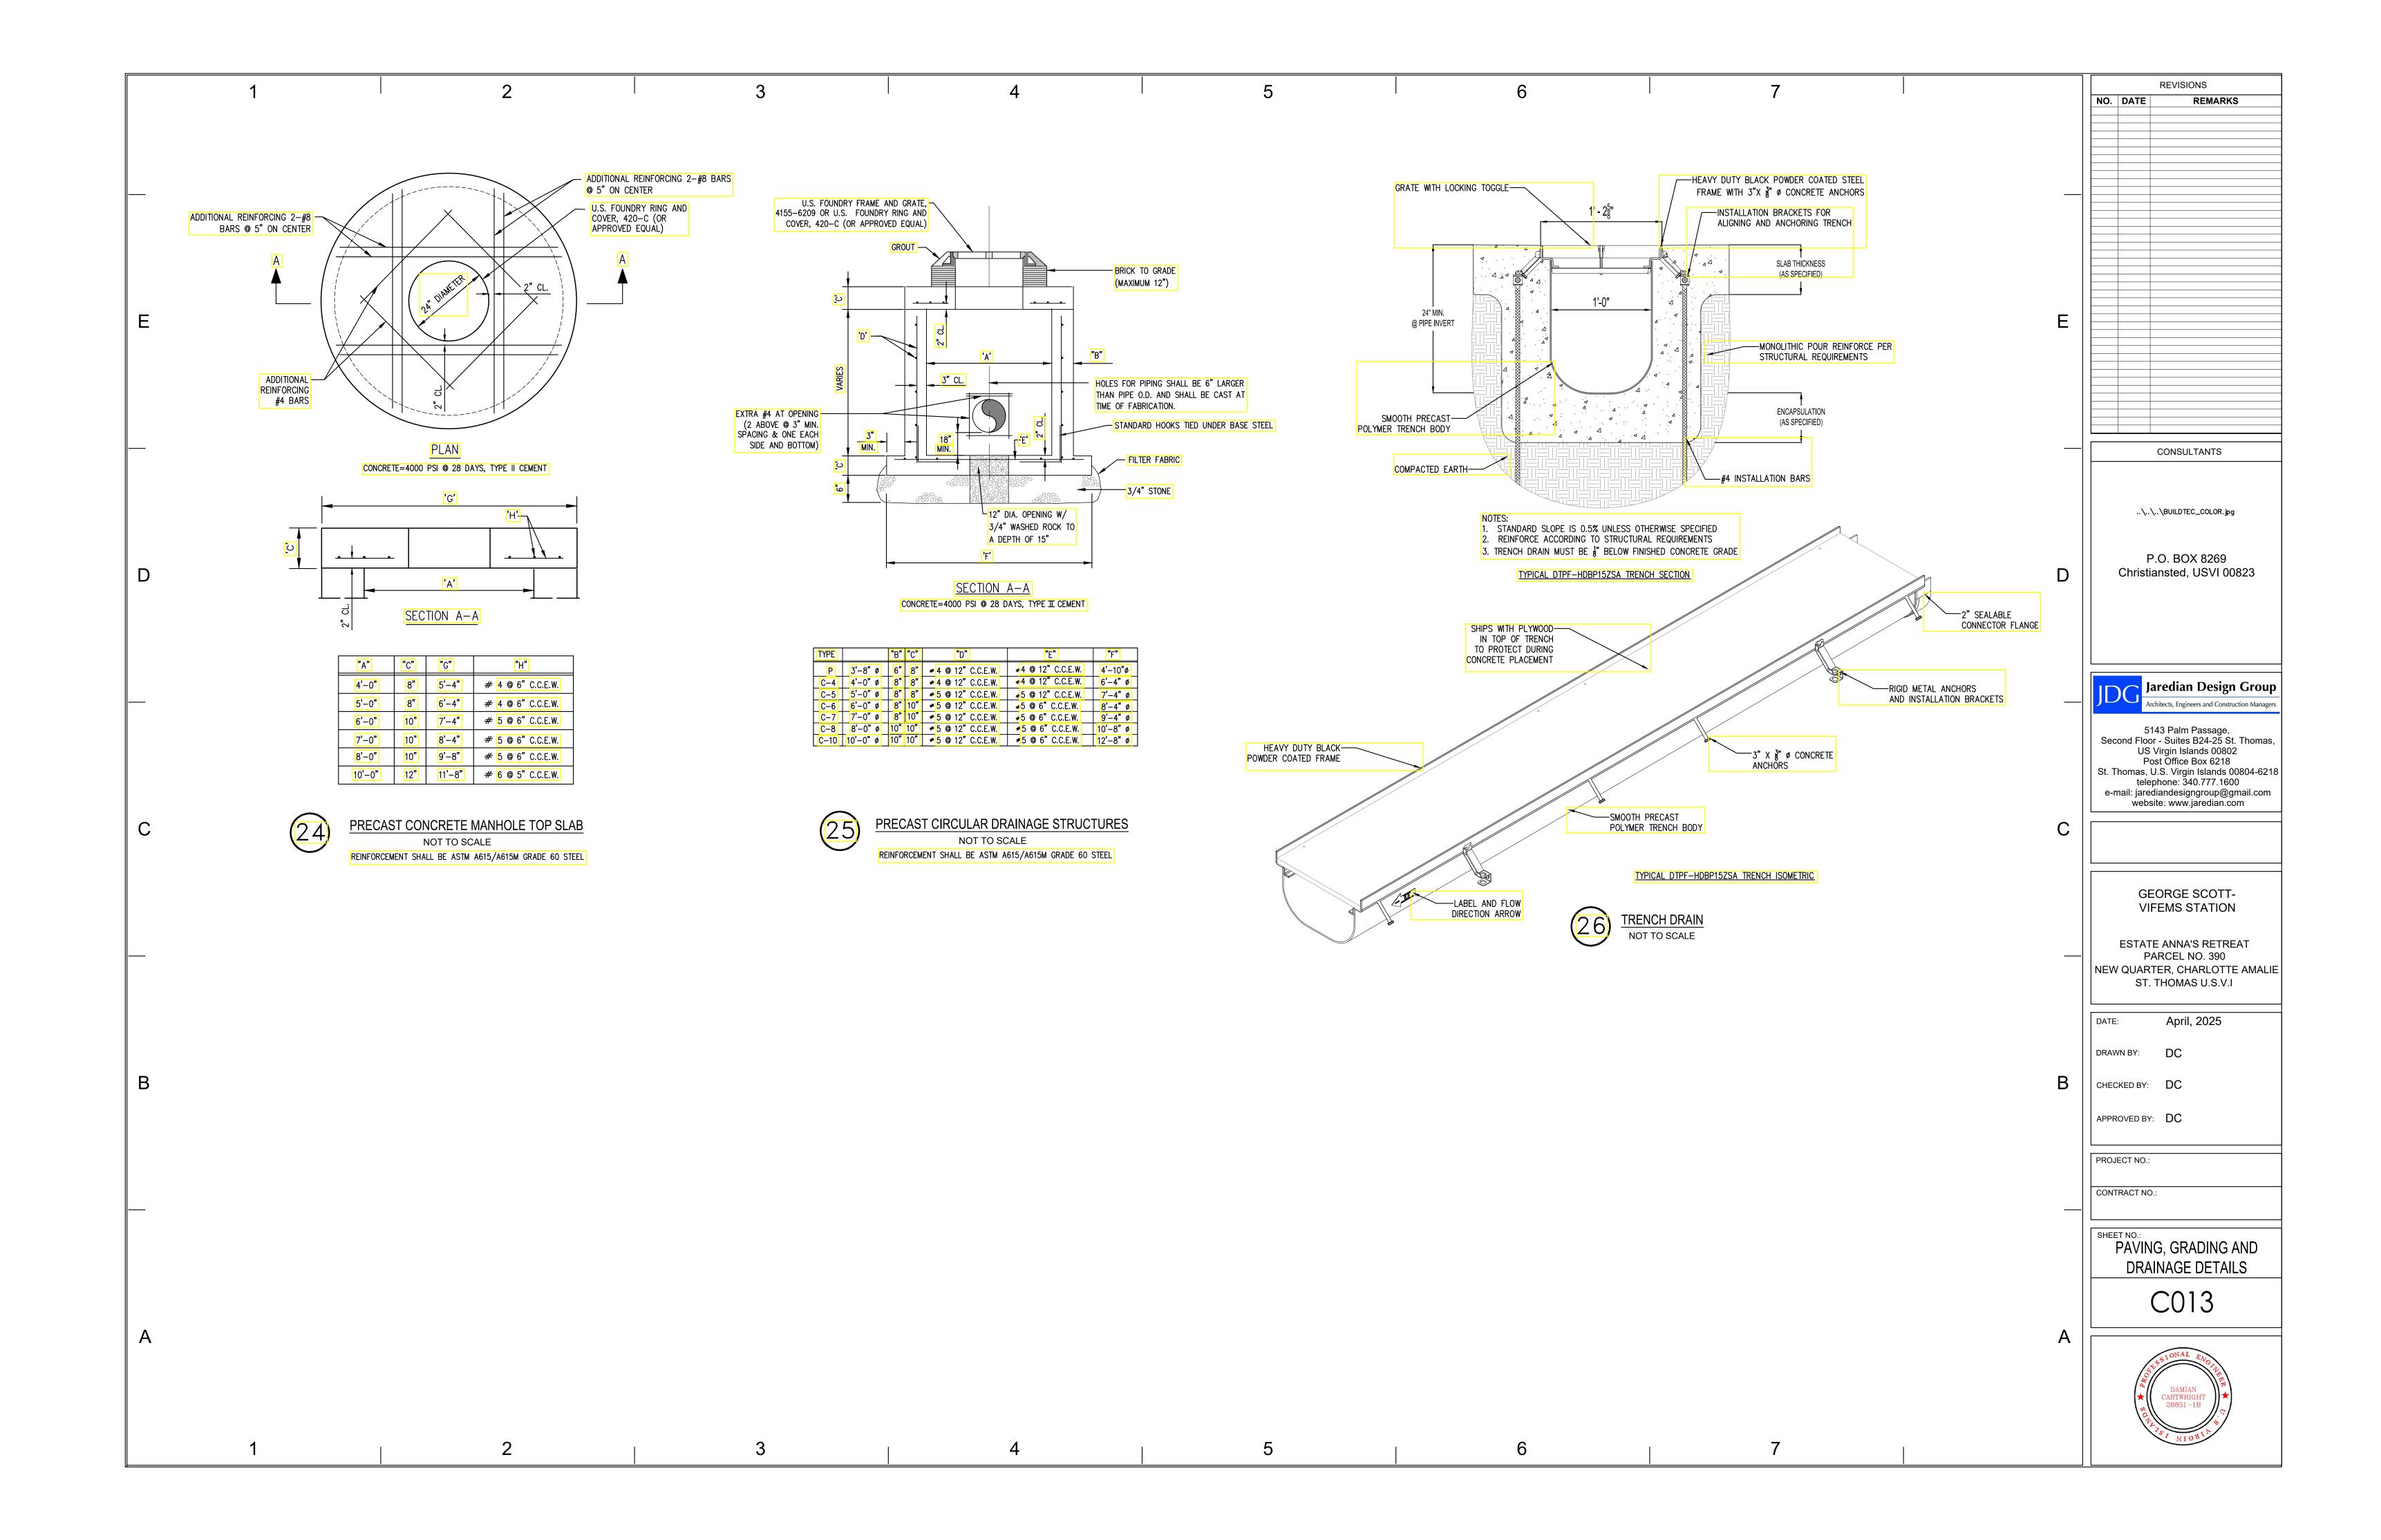

SC-740 Chamber Designed to meet the most stringent industry performance standards for superior structural integrity **Storage Volume Per Chamber** SC-740 Cumulative Storage Volumes per chamber while providing designers with a cost-effective method to save valuable land and protect water resources. Assumes 40% Stone Porosity. Calculations are Based Ε The StormTech system is designed primarily to be used under parking lots, thus maximizing land usage for Upon a 6" (150 mm) Stone Base Under Chambers. private (commercial) and public applications. StormTech chambers can also be used in conjunction with Green Infrastructure, thus enhancing the performance and extending the service life of these practices. StormTech SC-740 Chamber (not to scale) mm) row spacing and 40% stone porosity. Nominal Specifications **Amount of Stone Per Chamber** 85.4" x 51.0" x 30.0" Size (Lx W x H) (2,170 x 1,295 x 762 mm) 45.9 ft³ (1.30 m³) Chamber Storage 74.9 ft³ (2.12 m³) Min. Installed Storage* Weight 74.0 lbs (33.6 kg) D *Assumes 6" (150 mm) stone above, below and between Note: Assumes 6" (150 mm) of stone above and between chambers and 40% stone porosity. chambers. Shipping **Volume Excavation Per Chamber** 30 chambers/pallet 90.7" (2304 mm) ACTUAL LENGTH 60 end caps/pallet 24" (600 mm) 12 pallets/truck – DIAMETER MAX. (744 mm) cover increases. (310 mm) 45.9" (1166 mm) C 85.4" (2169 mm) INSTALLED LENGTH (762 mm) (1295 mm)

EMBEDMENT STONE SHALL BE A CLEAN, CRUSHED AND ANGULAR GRANULAR WELL-GRADED SOIL/AGGREGATE MIXTURES, <35% STONE WITH AN AASHTO M43 DESIGNATION BETWEEN #3 AND #57 FINES, COMPACT IN 6" (150 mm) MAX LIFTS TO 95% PROCTOR DENSITY. SEE THE TABLE OF ACCEPTABLE FILL MATERIALS. CHAMBERS SHALL MEET THE REQUIREMENTS FOR ASTM F2418 POLYPROPLENE (PP) CHAMBERS -CHAMBERS SHALL BE BE DESIGNED IN ACCORDANCE WITH ASTM F2787 OR ASTM F2922 POLYETHYLENE (PE) CHAMBERS "STANDARD PRACTICE FOR STRUCTURAL DESIGN OF THERMOPLASTIC CORRUGATED WALL STORMWATER COLLECTION CHAMBERS". ADS GEOSYTHETICS 601T NON-WOVEN GEOTEXTILE ALL AROUND CLEAN, CRUSHED, PAVEMENT LAYER (DESIGNED ANGULAR EMBEDMENT STONE (450 mm) MIN* MAX 6" (150 mm) MIN PERIMETER STONE **EXCAVATION WALL** (CAN BE SLOPED OR VERTICAL) DEPTH OF STONE TO BE DETERMINED BY SITE DESIGN ENGINEER 6" (150 mm) MIN SITE DESIGN ENGINEER IS RESPONSIBLE FOR (150 mm) MIN — 51" (1295 mm) — THE ENSURING THE REQUIRED BEARING -

The installed chamber system shall provide the load factors specified in the aashto lrfd bridge design specifications section 12.12 for

*MINIMUM COVER TO BOTTOM OF FLEXIBLE PAVEMENT. FOR UNPAVED INSTALLATIONS WHERE RUTTING FROM VEHICLES MAY OCCUR, INCREASE COVER TO 24" (600 mm).

earth and live loads, with consideration for impact and multiple vehicle presences.

В

CAPACITY OF SUBGRADE SOILS

Depth of Water in System in. (mm)	Cumulative Chamber Storage ft³ (m³)	Total System Cumulative Storage ft³ (m³)
42 (1067)	45.90 (1.300)	74.90 (2.121)
41 (1041)	45.90 (1.300)	73.77 (2.089)
40 (1016)	Stone 45.90 (1.300)	72.64 (2.057)
39 (991)	Cover 45.90 (1.300)	71.52 (2.025)
38 (965)	45.90 (1.300)	70.39 (1.993)
37 (940)	4 5.90 (1.300)	69.26 (1.961)
36 (914)	45.90 (1.300)	68.14 (1.929)
35 (889)	45.85 (1.298)	66.98 (1.897)
34 (864)	45.69 (1.294)	65.75 (1.862)
33 (838)	45.41 (1.286)	64.46 (1.825)
32 (813)	44.81 (1.269)	62.97 (1.783)
31 (787)	44.01 (1.246)	w61.36 (1.737)
30 (762)	43.06 (1.219)	59.66 (1.689)
29 (737)	41.98 (1.189)	57.89 (1.639)
28 (711)	40.80 (1.155)	56.05 (1.587)
27 (686)	39.54 (1.120)	54.17 (1.534)
26 (660)	38.18 (1.081)	52.23 (1.479)
25 (635)	36.74 (1.040)	50.23 (1.422)
24 (610)	35.22 (0.977)	48.19 (1.365)
23 (584)	33.64 (0.953)	46.11 (1.306)
22 (559)	31.99 (0.906)	44.00 (1.246)
21 (533)	30.29 (0.858)	1.85 (1.185)
20 (508)	28.54 (0.808)	39.67 (1.123)
19 (483)	26.74 (0.757)	37.47 (1.061)
18 (457)	24.89 (0.705)	35.23 (0.997)
17 (432)	23.00 (0.651)	32.96 (0.939)
16 (406)	21.06 (0.596)	30.68 (0.869)
15 (381)	19.09 (0.541)	28.36 (0.803)
14 (356)	17.08 (0.484)	26.03 (0.737)
13 (330)	15.04 (0.426)	23.68 (0.670)
12 (305)	12.97 (0.367)	21.31 (0.608)
11 (279)	10.87 (0.309)	18.92 (0.535)
10 (254)	8.74 (0.247)	16.51 (0.468)
9 (229)	6.58 (0.186)	14.09 (0.399)
8 (203)	4.41 (0.125)	11.66 (0.330)
7 (178)	2.21 (0.063)	9.21 (0.264)
6 (152)	0 (0)	6.76 (0.191)
5 (127)	0 (0)	5.63 (0.160)
4 (102)	Stone 0 (0)	4.51 (0.128)
3 (76)	Foundation 0 (0)	3.38 (0.096)
2 (51)	0 (0)	2.25 (0.064)
1 (25)	0 (0)	1.13 (0.032)

(25 mm) of stone foundation.

ft³ (m³)	ft³ (m³) Bare Chamber Foundation Depth in. (r			
,	Storage ft³ (m³)	6 (150)	12 (300)	18 (450)
SC-740	45.9 (1.3)	74.9 (2.1)	81.7 (2.3)	88.4 (2.5)

Note: Assumes 6" (150 mm) stone above chambers, 6" (150

TONS (yds³)	Stone Foundation Depth		
TONS (yus ²)	6	12	16
SC-740	3.8 (2.8)	4.6 (3.3)	5.5 (3.9)
KILOGRAMS (m³)	150 mm	300 mm	450 mm
SC-740	3,450 (2.1)	4,170 (2.5)	4,490 (3.0)

vel3 (ma3)	Stone Foundation Depth		
yd³ (m³)	6 (150)	12 (300)	18 (450)
SC-740	5.5 (4.2)	6.2 (4.7)	6.8 (5.2)

Note: Assumes 6" (150 mm) of row separation and 18" (450 mm) of cover. The volume of excavation will vary as depth of



CONSULTANTS ..\..\..\BUILDTEC_COLOR.jpg P.O. BOX 8269 Christiansted, USVI 00823 Jaredian Design Group 5143 Palm Passage, Second Floor - Suites B24-25 St. Thomas,

REMARKS

NO. DATE

GEORGE SCOTT-VIFEMS STATION

US Virgin Islands 00802 Post Office Box 6218

St. Thomas, U.S. Virgin Islands 00804-6218

telephone: 340.777.1600

e-mail: jarediandesigngroup@gmail.com website: www.jaredian.com

ESTATE ANNA'S RETREAT PARCEL NO. 390 NEW QUARTER, CHARLOTTE AMALIE ST. THOMAS U.S.V.I

April, 2025

DRAWN BY: DC CHECKED BY: DC

PROJECT NO.: CONTRACT NO.:

APPROVED BY: DC

DATE:

PAVING, GRADING AND DRAINAGE DETAILS


C014





Note: Add 1.13 ft³ (0.032 m³) of storage for each additional inch


11



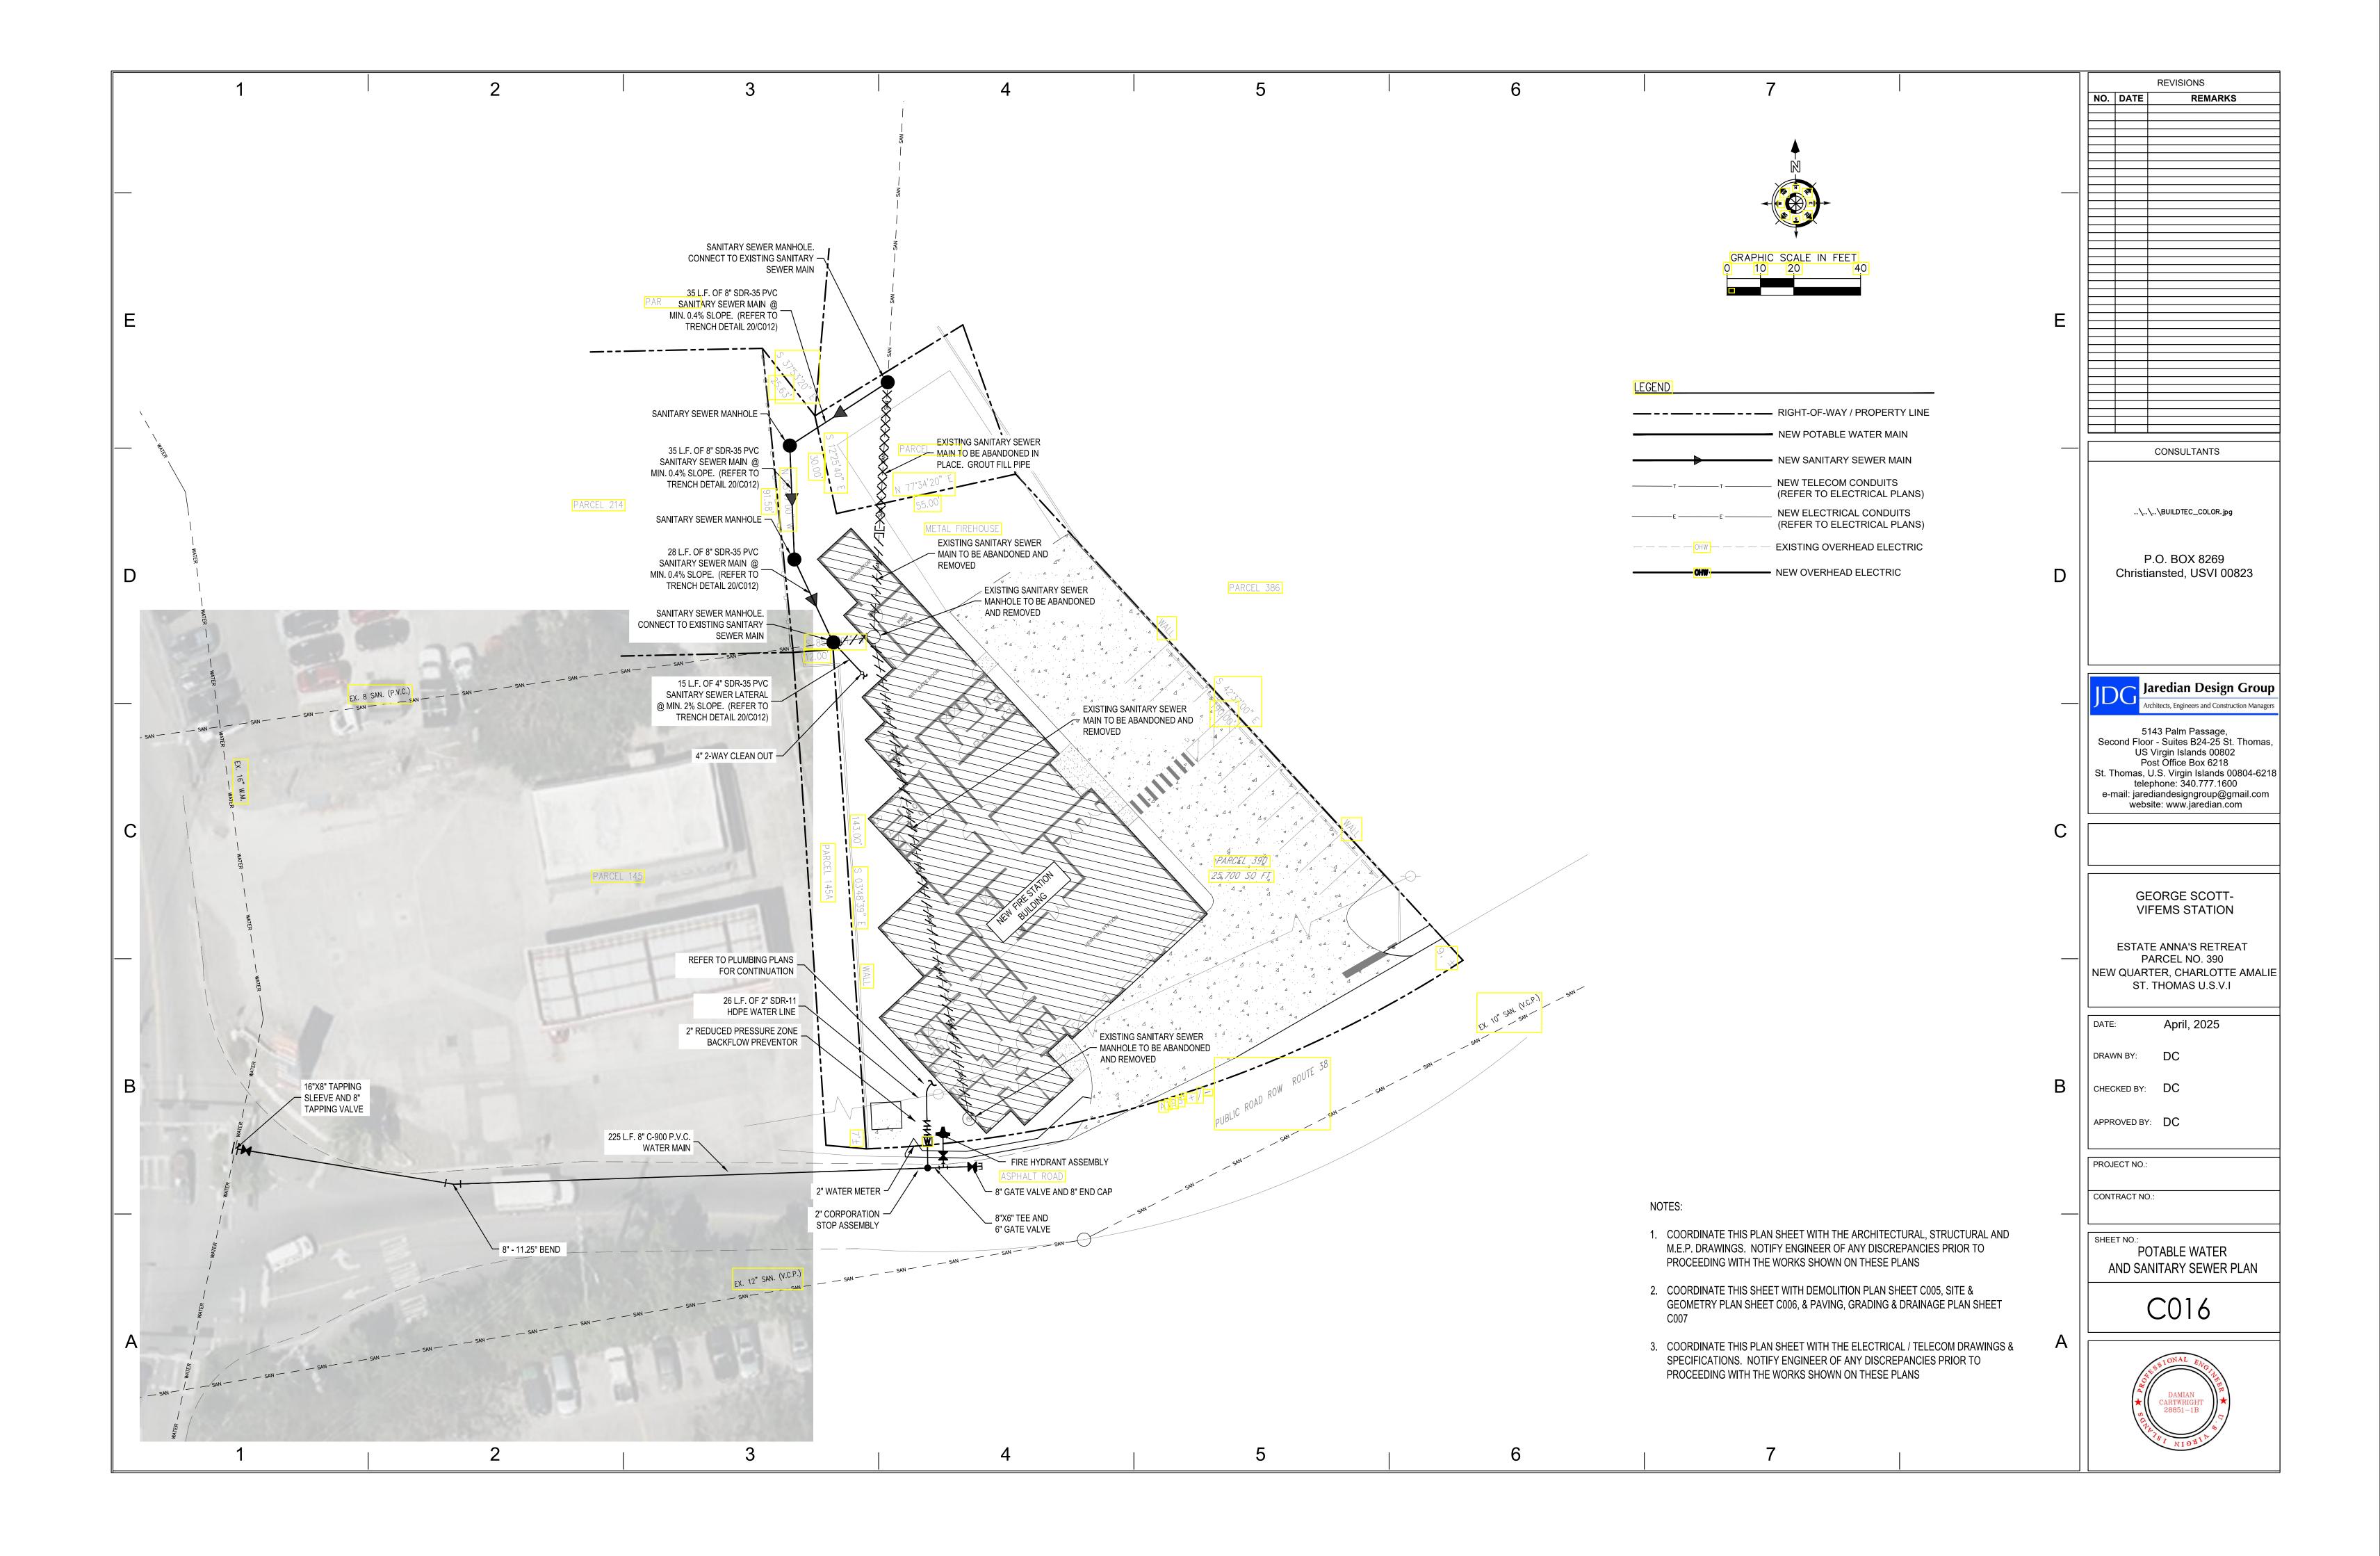

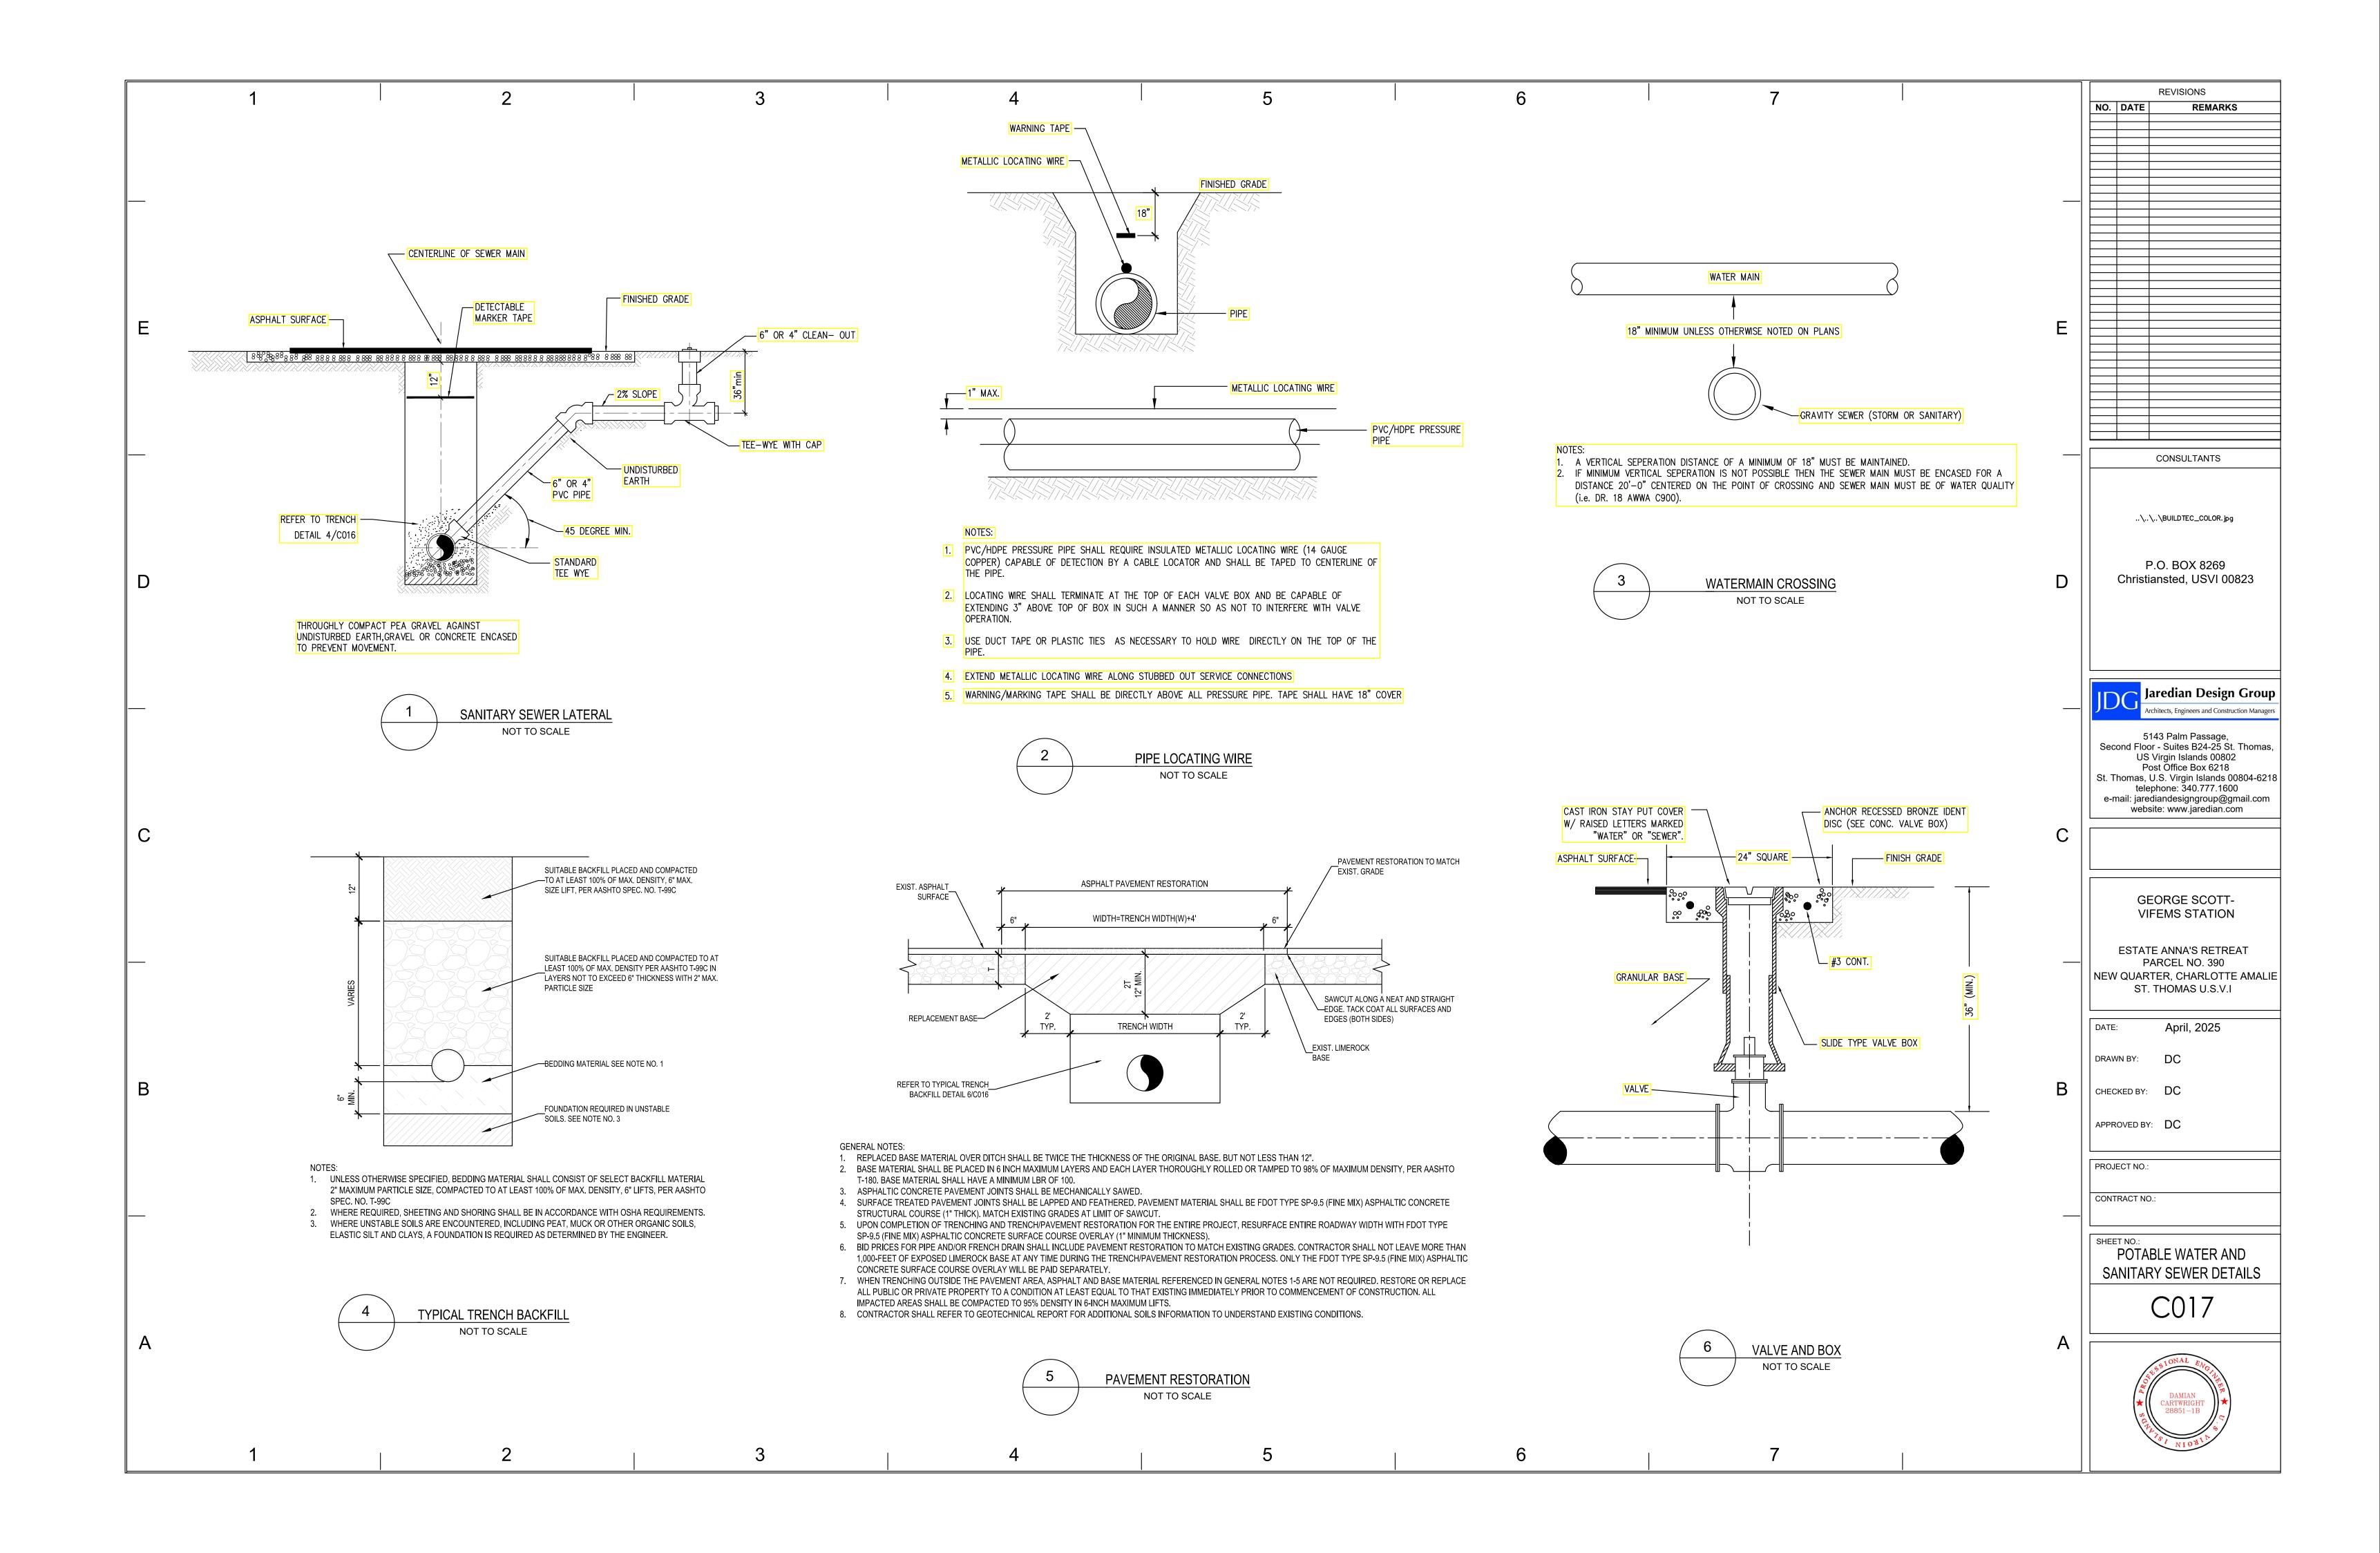

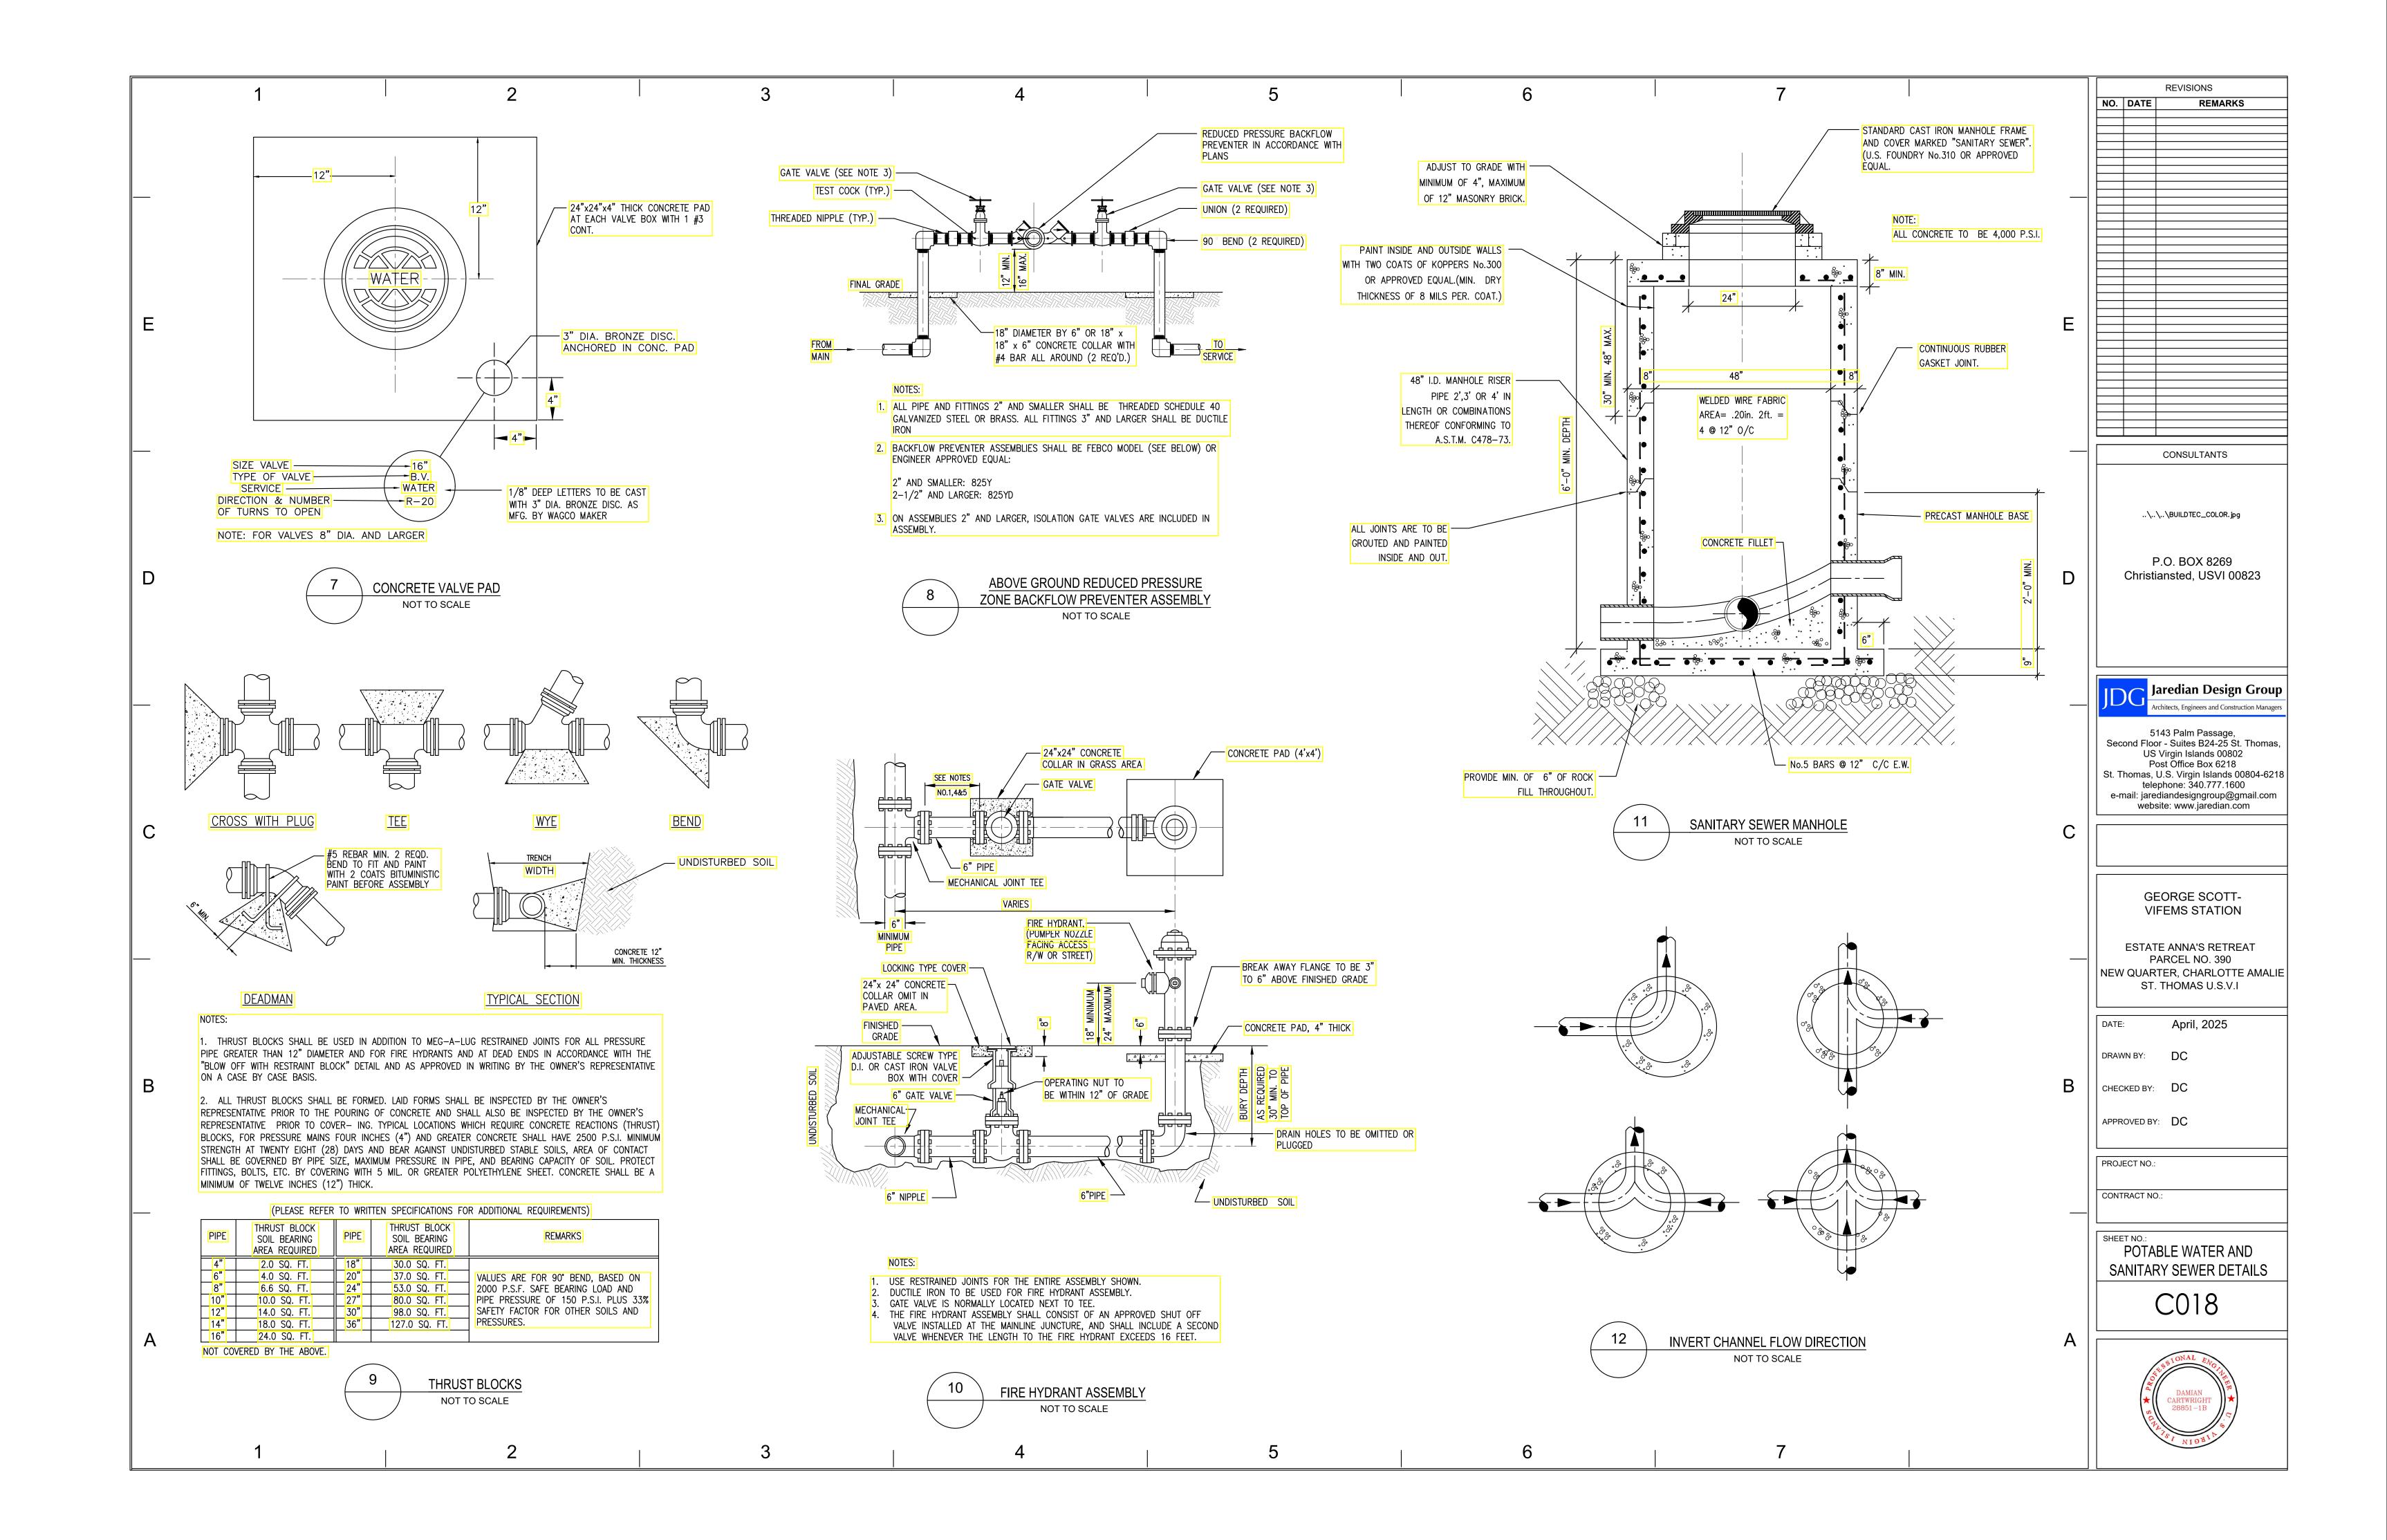

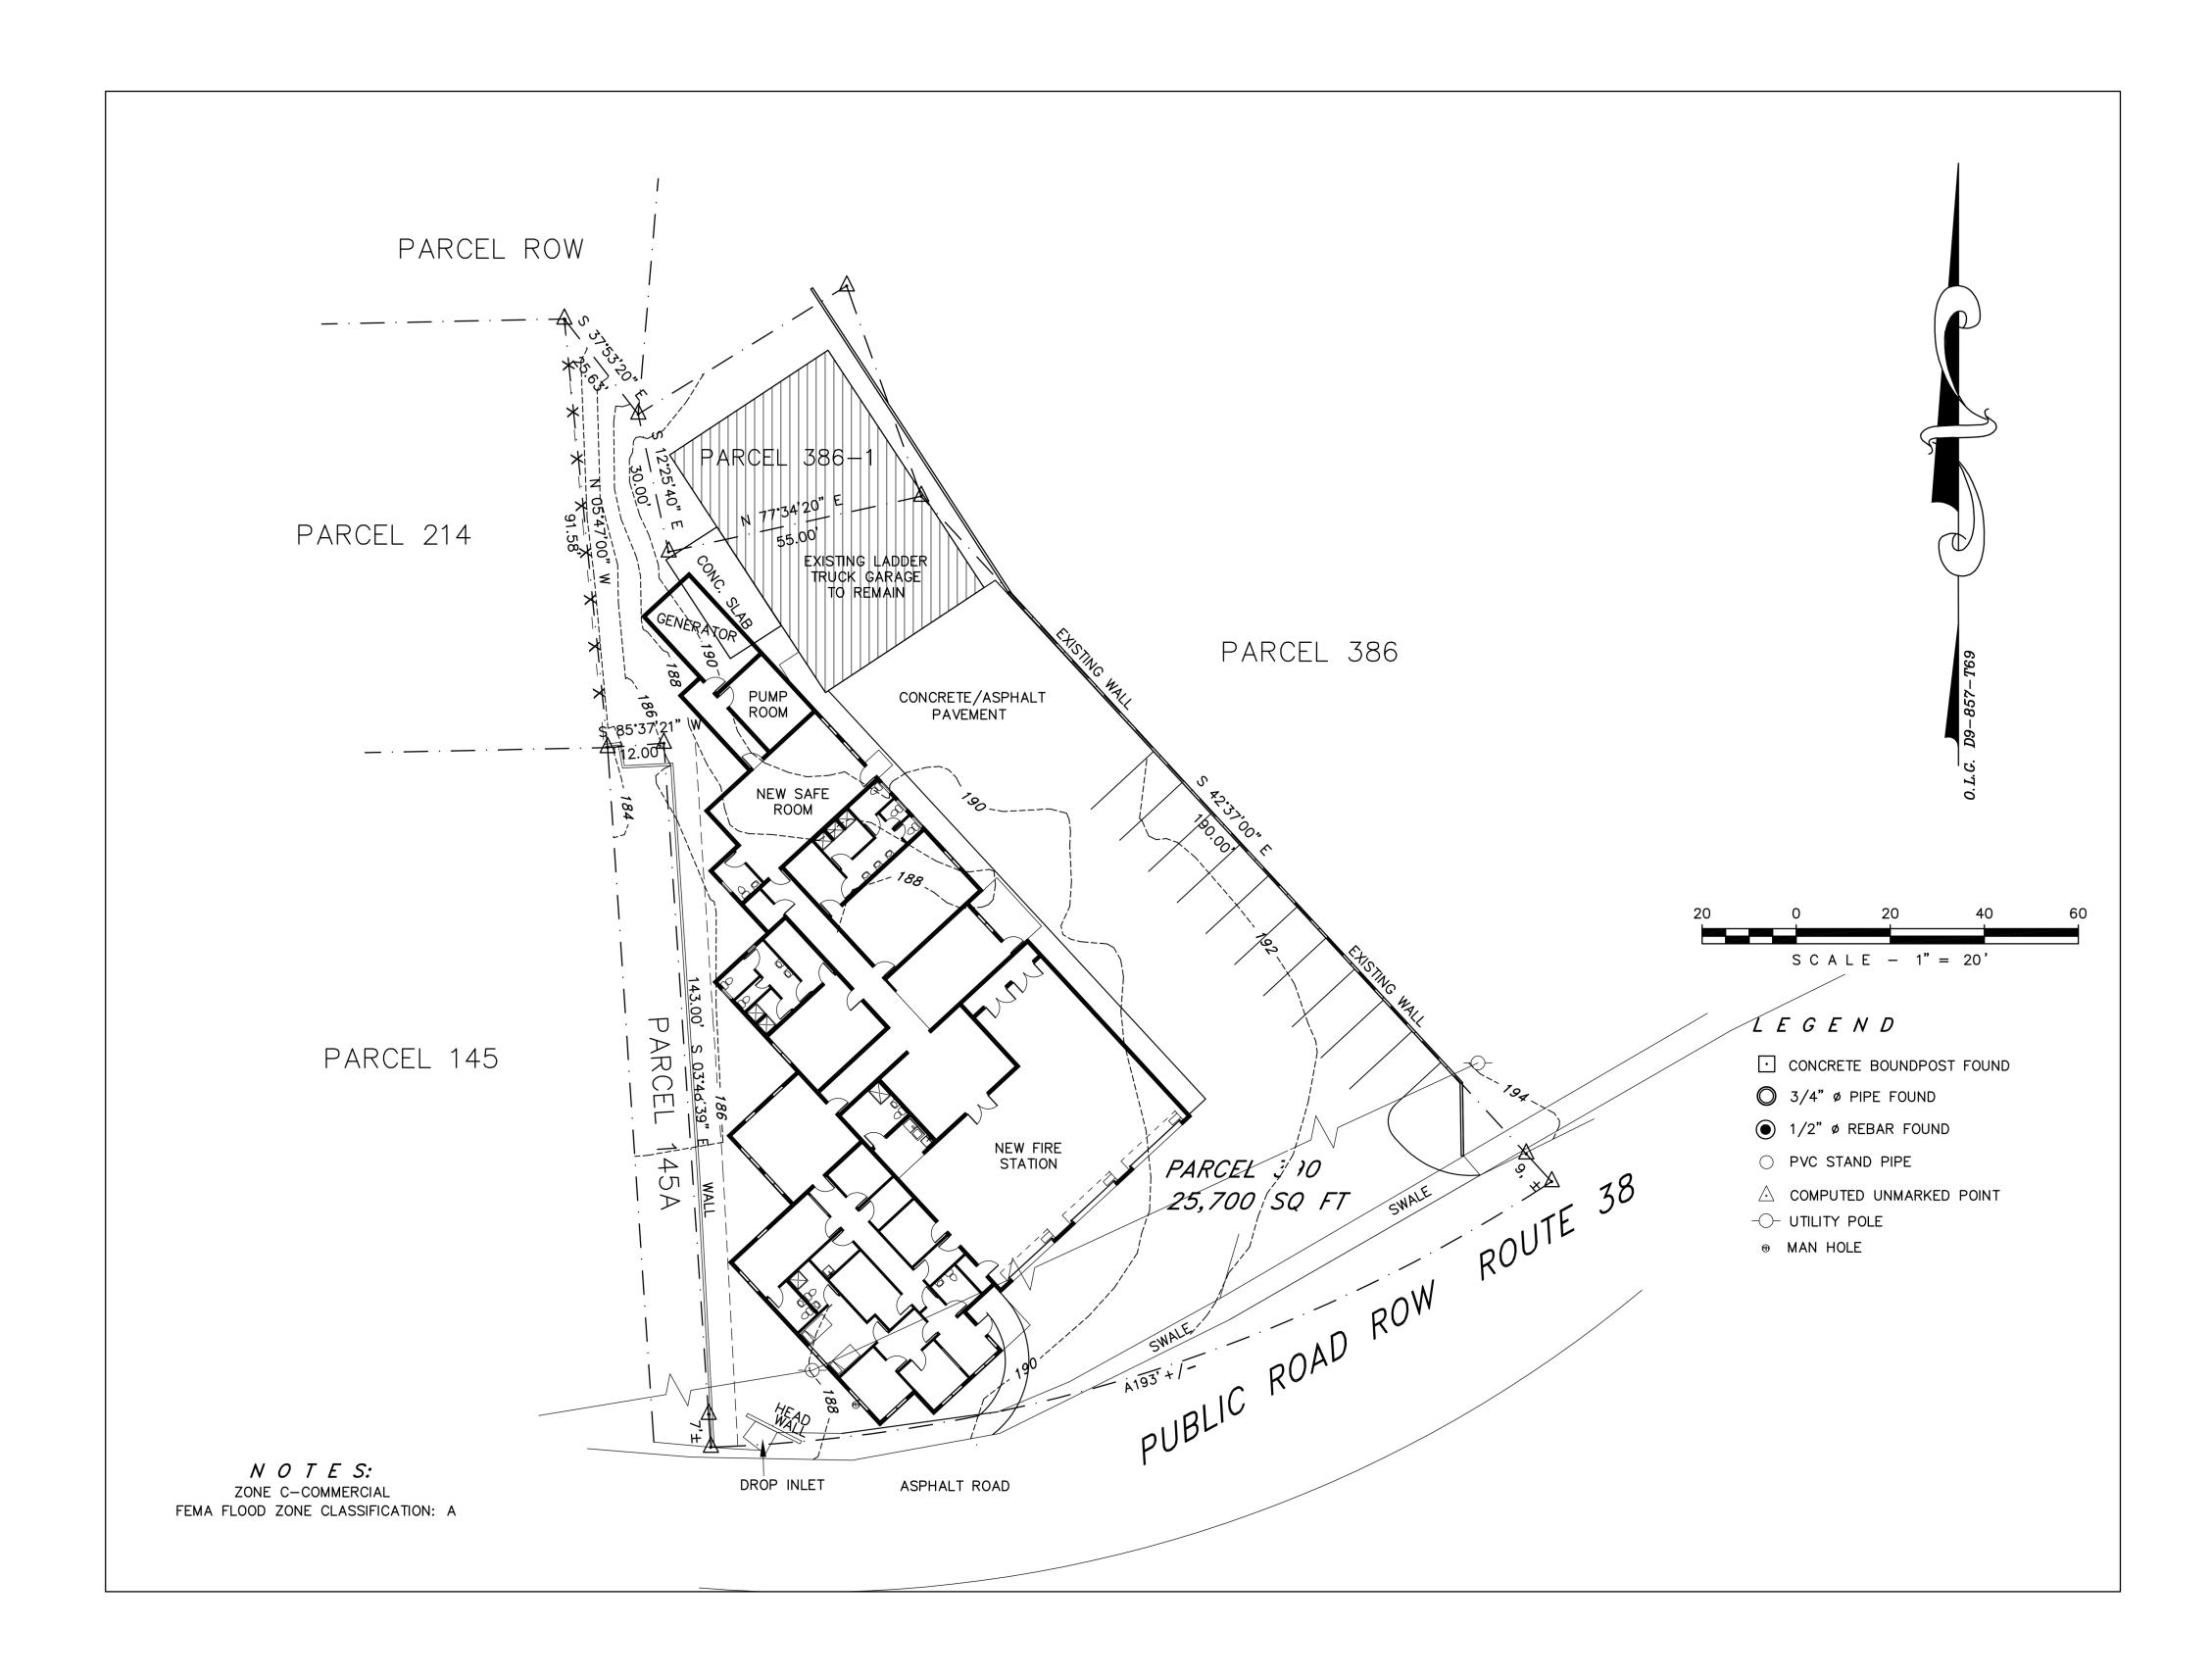







JAREDIAN DESIGN GROUP

5143 PALM PASSAGE, SECOND FLOOR - SUITES B24-25 ST. THOMAS, USVI 00802

EMAIL: jarediandesigngroup@gmail.com

CONSULTING ARCHITECT

BOSCHULTE ARCHITECTURE, LLC

PO Box 303190 St. Thomas, VI 00803

phone: (340) 777-2375 e-mail: info@boschulte.com website: www.boschulte.com






90

		S	
PRO	OGRESS SET		
No.	Descri	otion	Date
REV	/ISIONS		
No.	Descrip	otion	Date
Proj	ect number	202	1.007.04
Date	9	4/	15/2025
Drav	wn by		JTB
Che	cked by		JTR

ARCHITECTURAL SITE PLAN

AS101

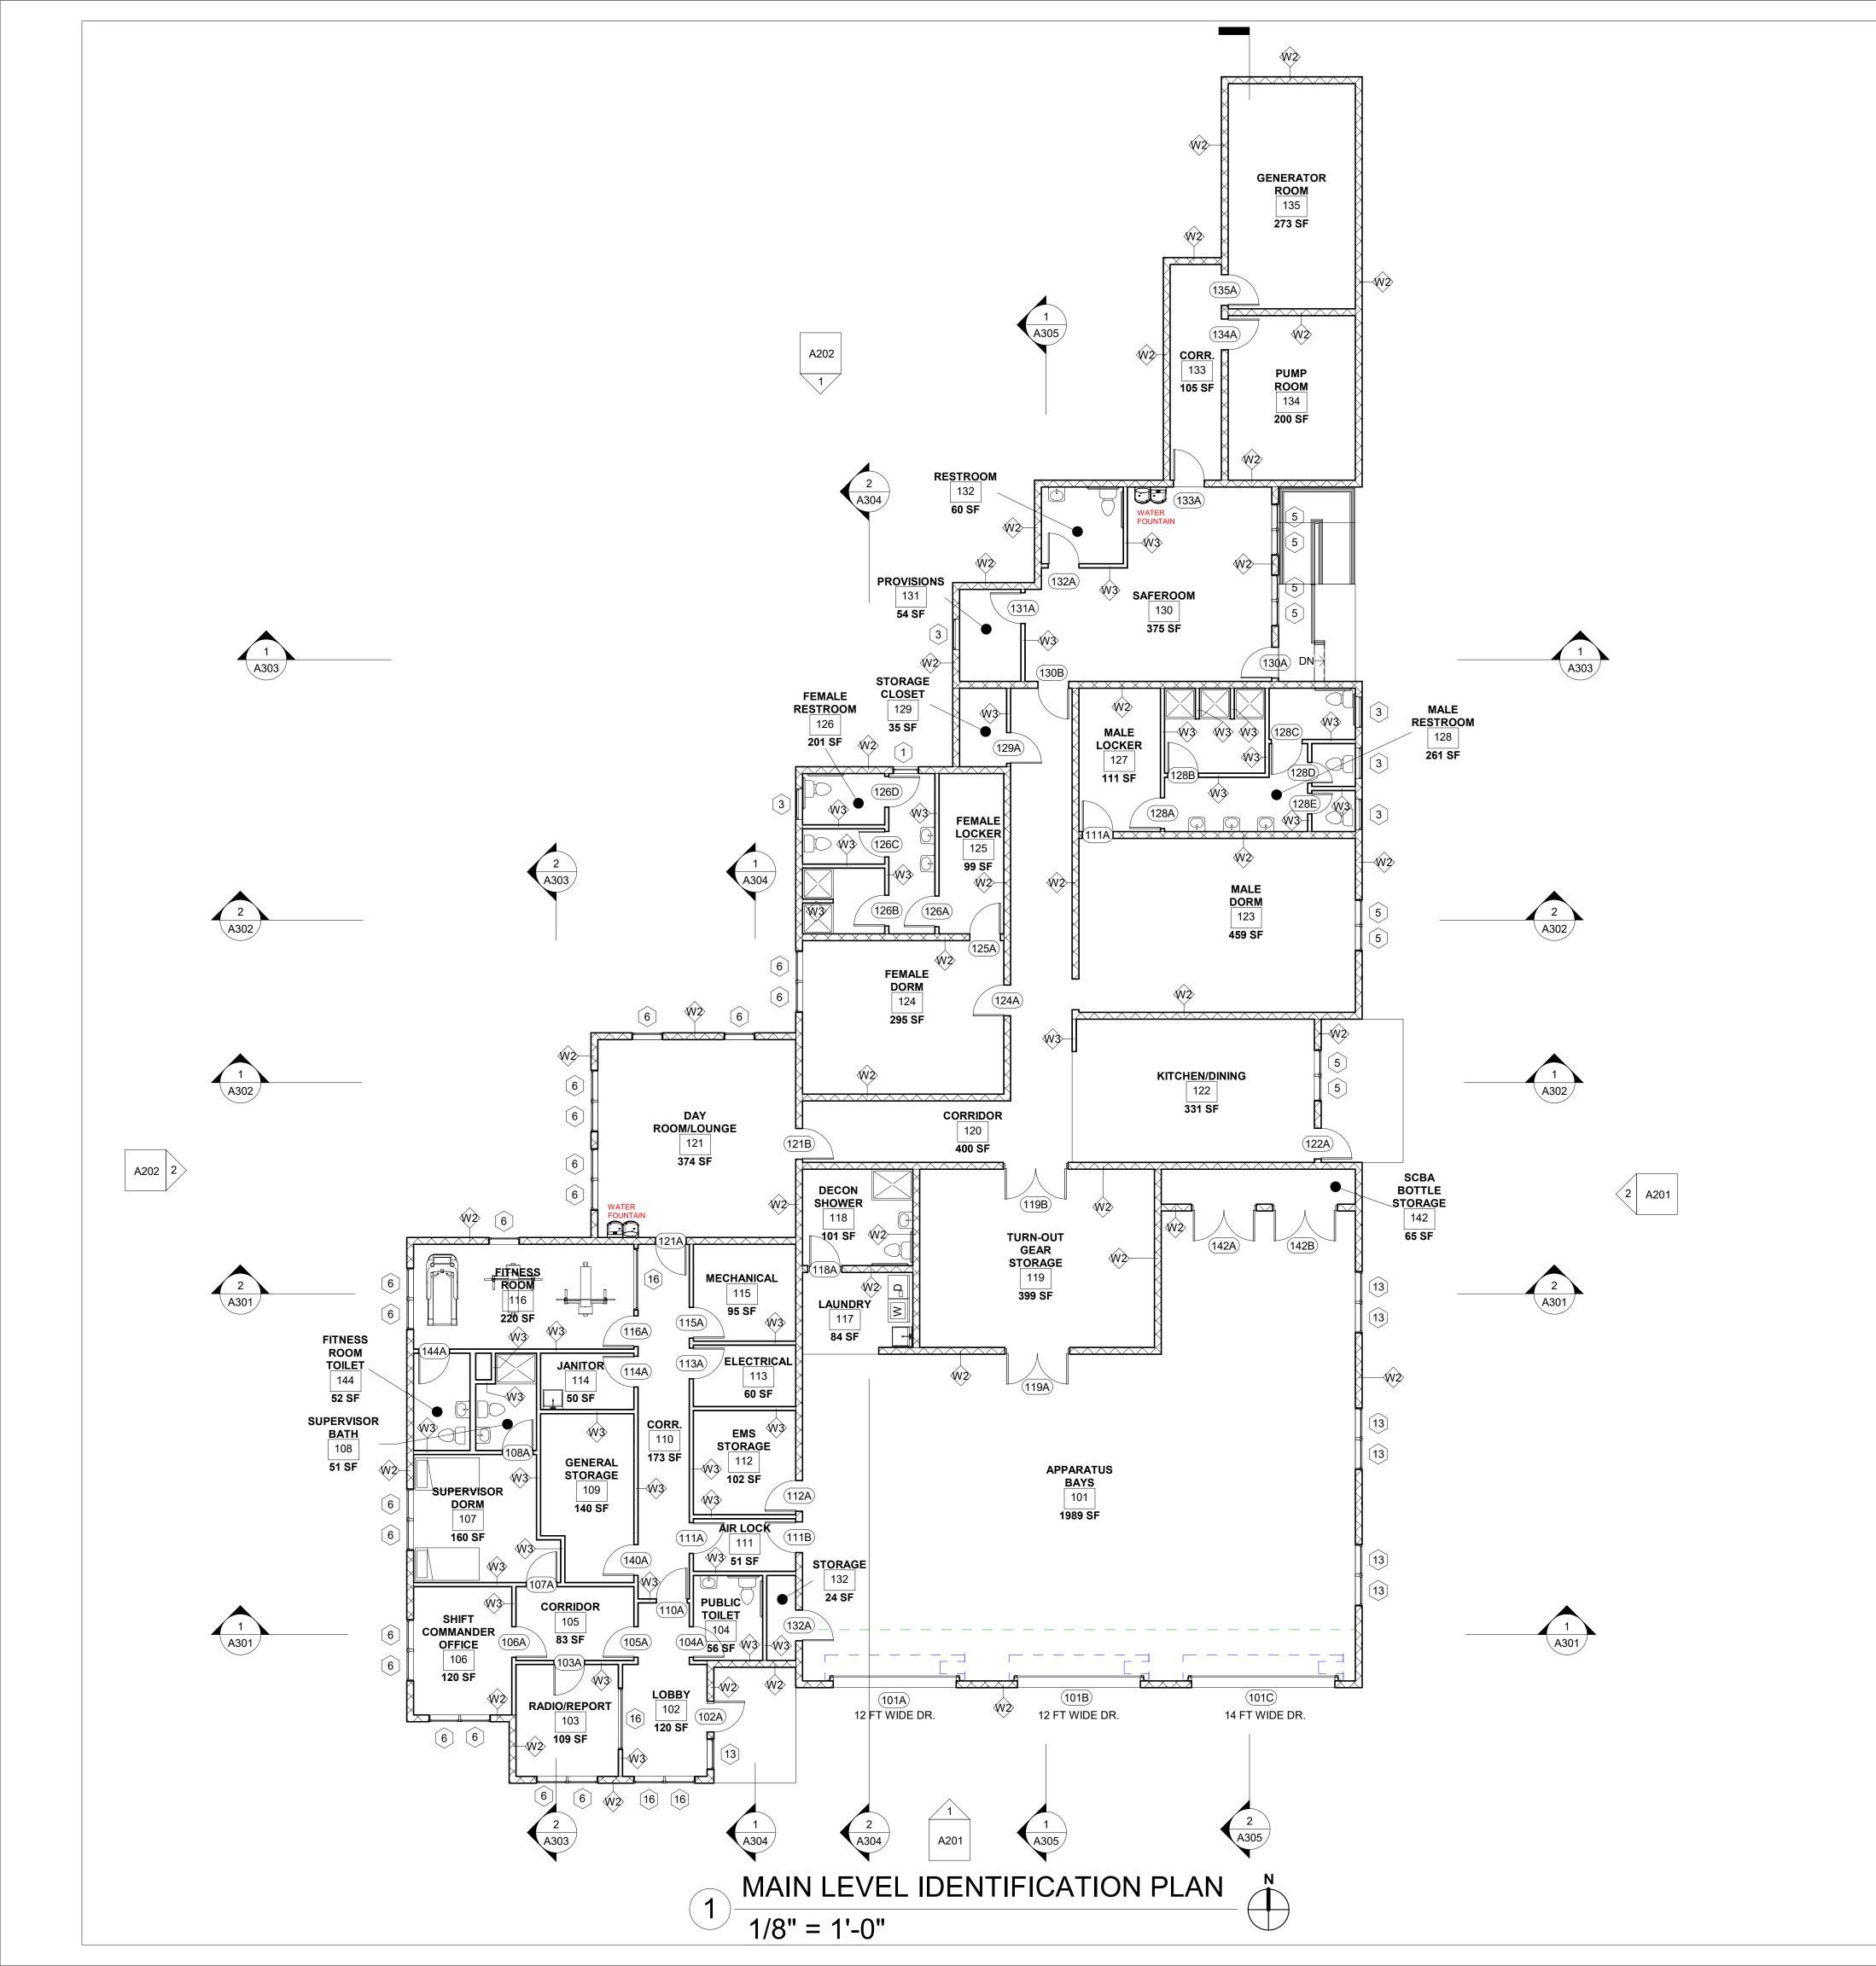





JAREDIAN DESIGN GROUP

5143 PALM PASSAGE, SECOND FLOOR - SUITES B24-25 ST. THOMAS, USVI 00802

PHONE: 340-777-1600

EMAIL: jarediandesigngroup@gmail.com

CONSULTING ARCHITECT

BOSCHULTE ARCHITECTURE, LLC

PO Box 303190 St. Thomas, VI 00803


phone: (340) 777-2375 e-mail: info@boschulte.com website: www.boschulte.com



FIRE STATION
LIMA COMPANY
390 ESTATE ANNAS RETREA
ST. THOMAS, U.S.V.I.

	OGRESS SET		
lo.	Descrip		Date
1	SCHEMATIC DESIGN		8/17/2024
RE	VISIONS		
o.	Descrip	tion	Date
Pro	ject number	2021.0	07.04
	te	4/15	/2025
Dat	Inc.		JTB
	awn by		
Dra	ecked by		JTB

A101

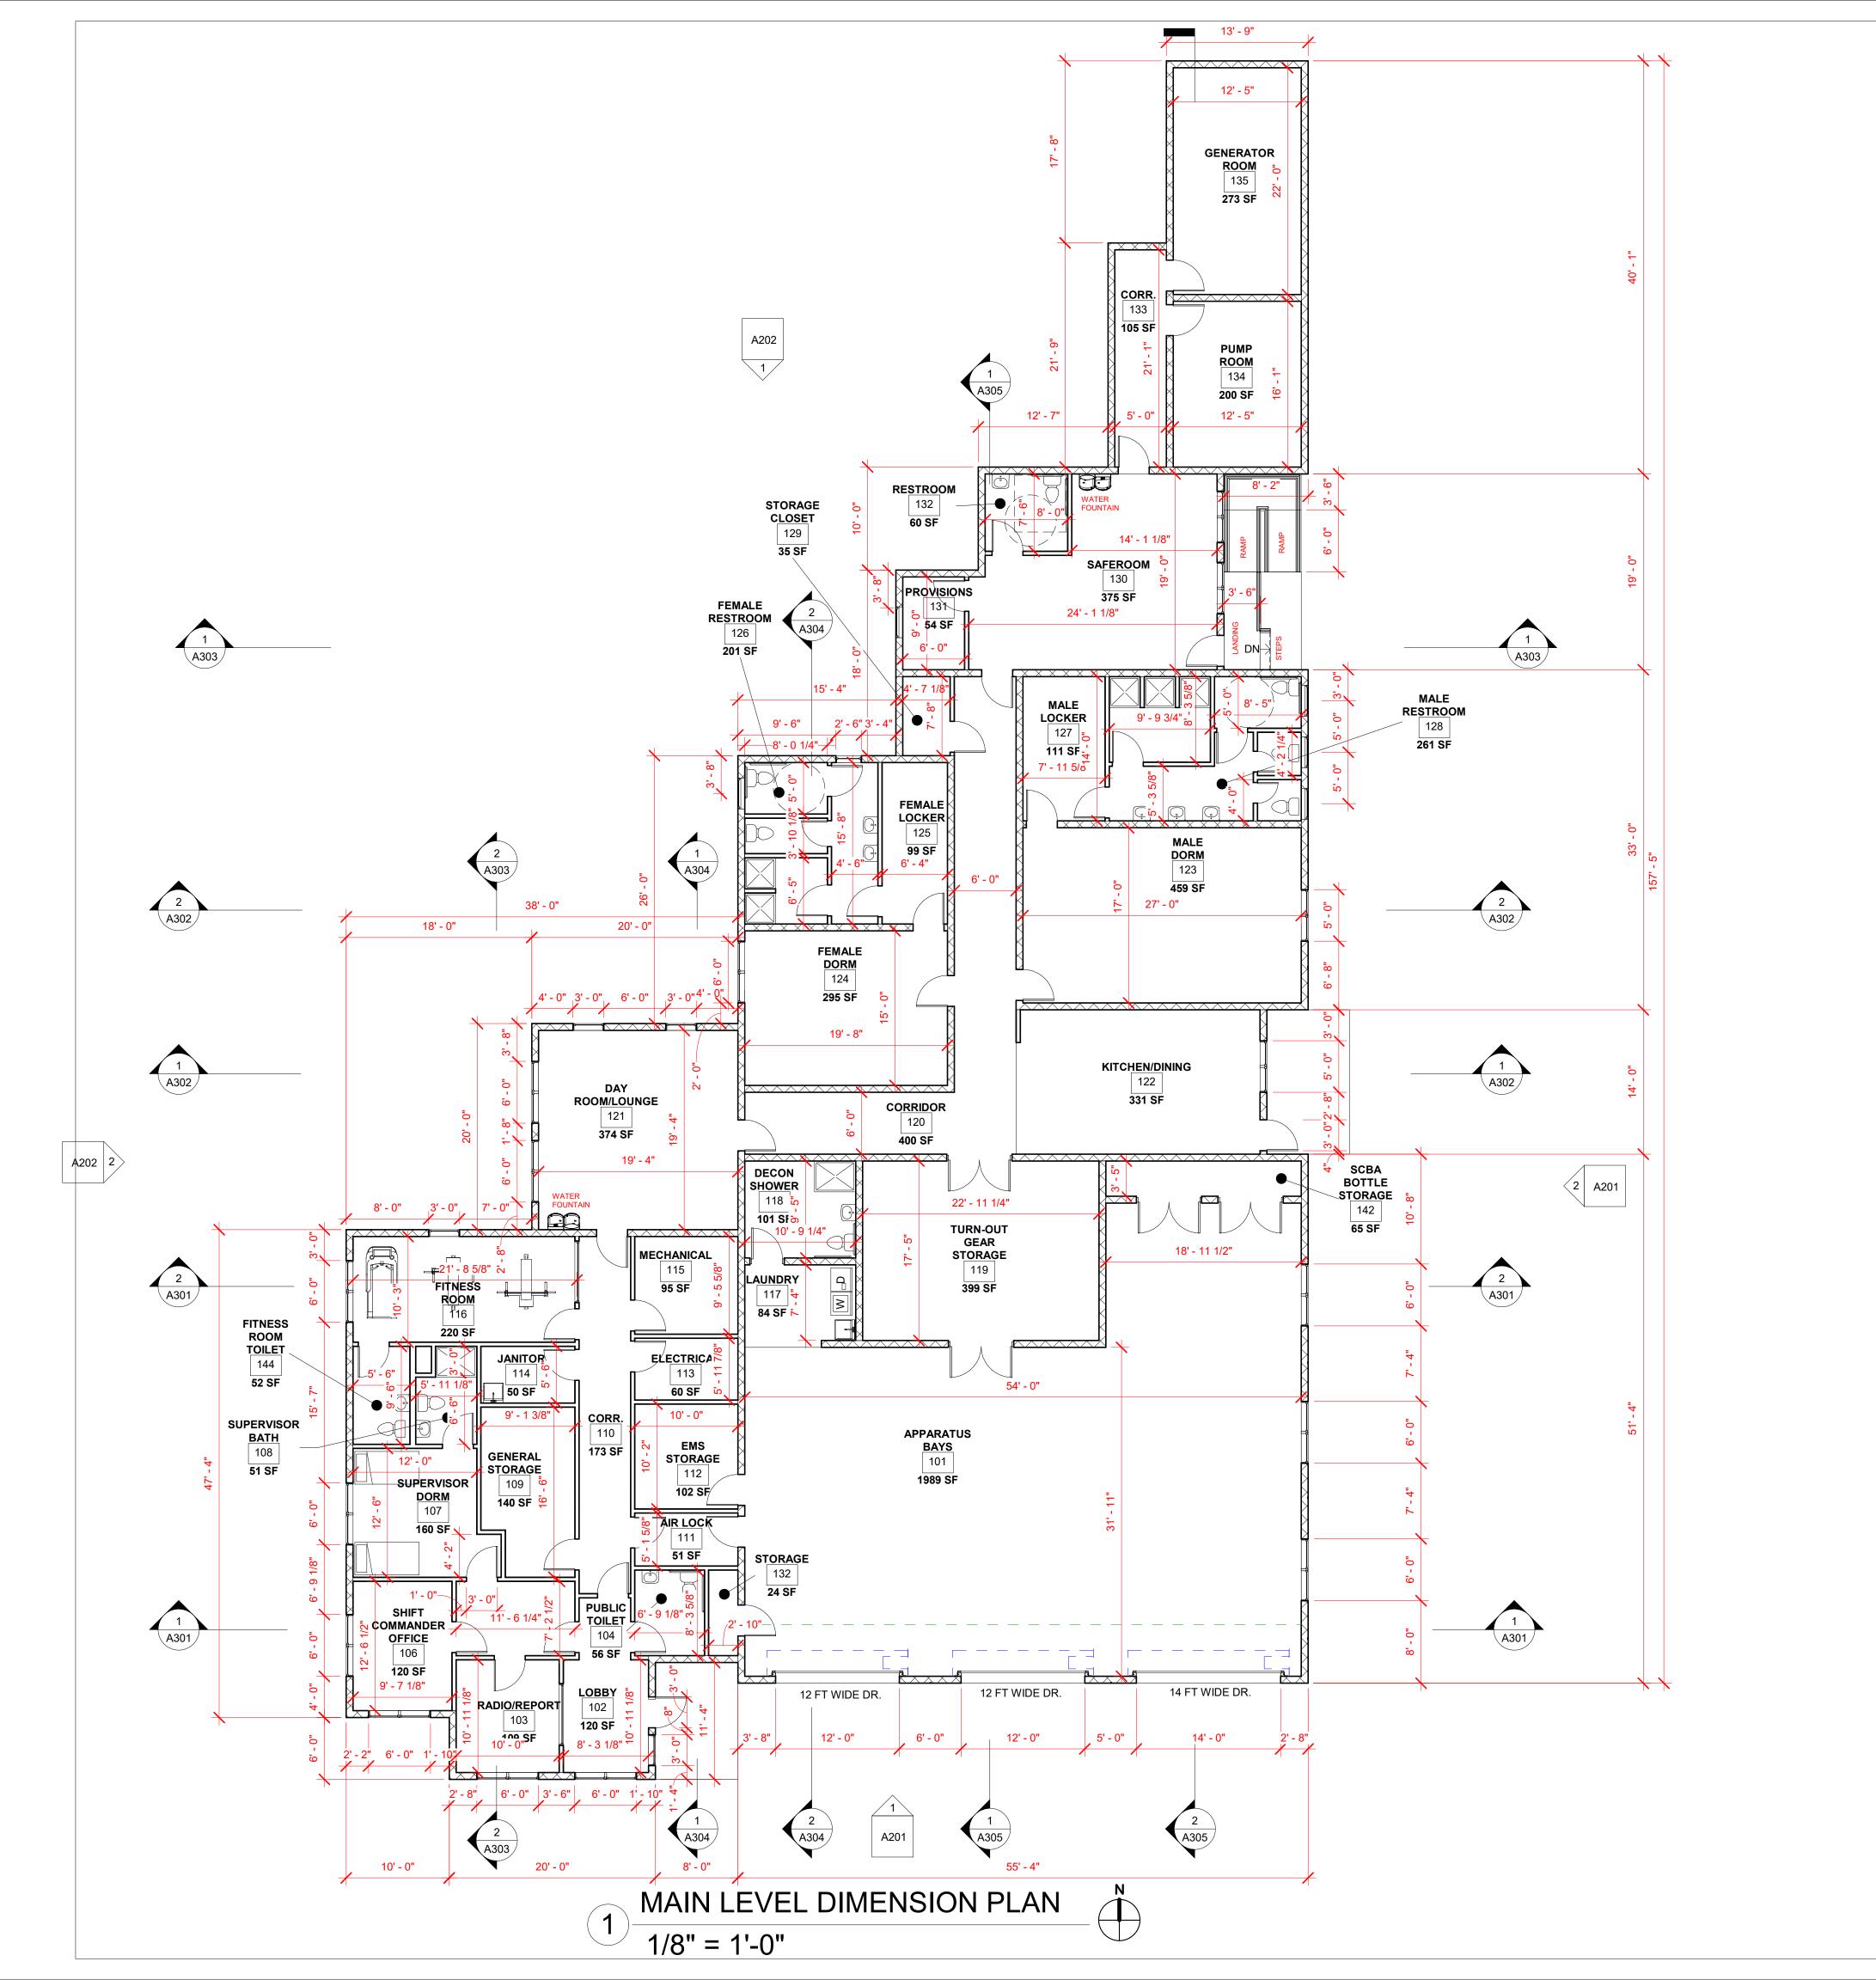





JAREDIAN DESIGN GROUP

5143 PALM PASSAGE, SECOND FLOOR - SUITES B24-25 ST. THOMAS, USVI 00802

PHONE: 340-777-1600

EMAIL: jarediandesigngroup@gmail.com CONSULTING ARCHITECT

BOSCHULTE ARCHITECTURE, LLC

PO Box 303190 St. Thomas, VI 00803

phone: (340) 777-2375 e-mail: info@boschulte.com website: www.boschulte.com




390


PROGRESS SET REVISIONS 2021.007.04 4/15/2025 JTB JTB Checked by

DIMENSION FLOOR PLAN


A102

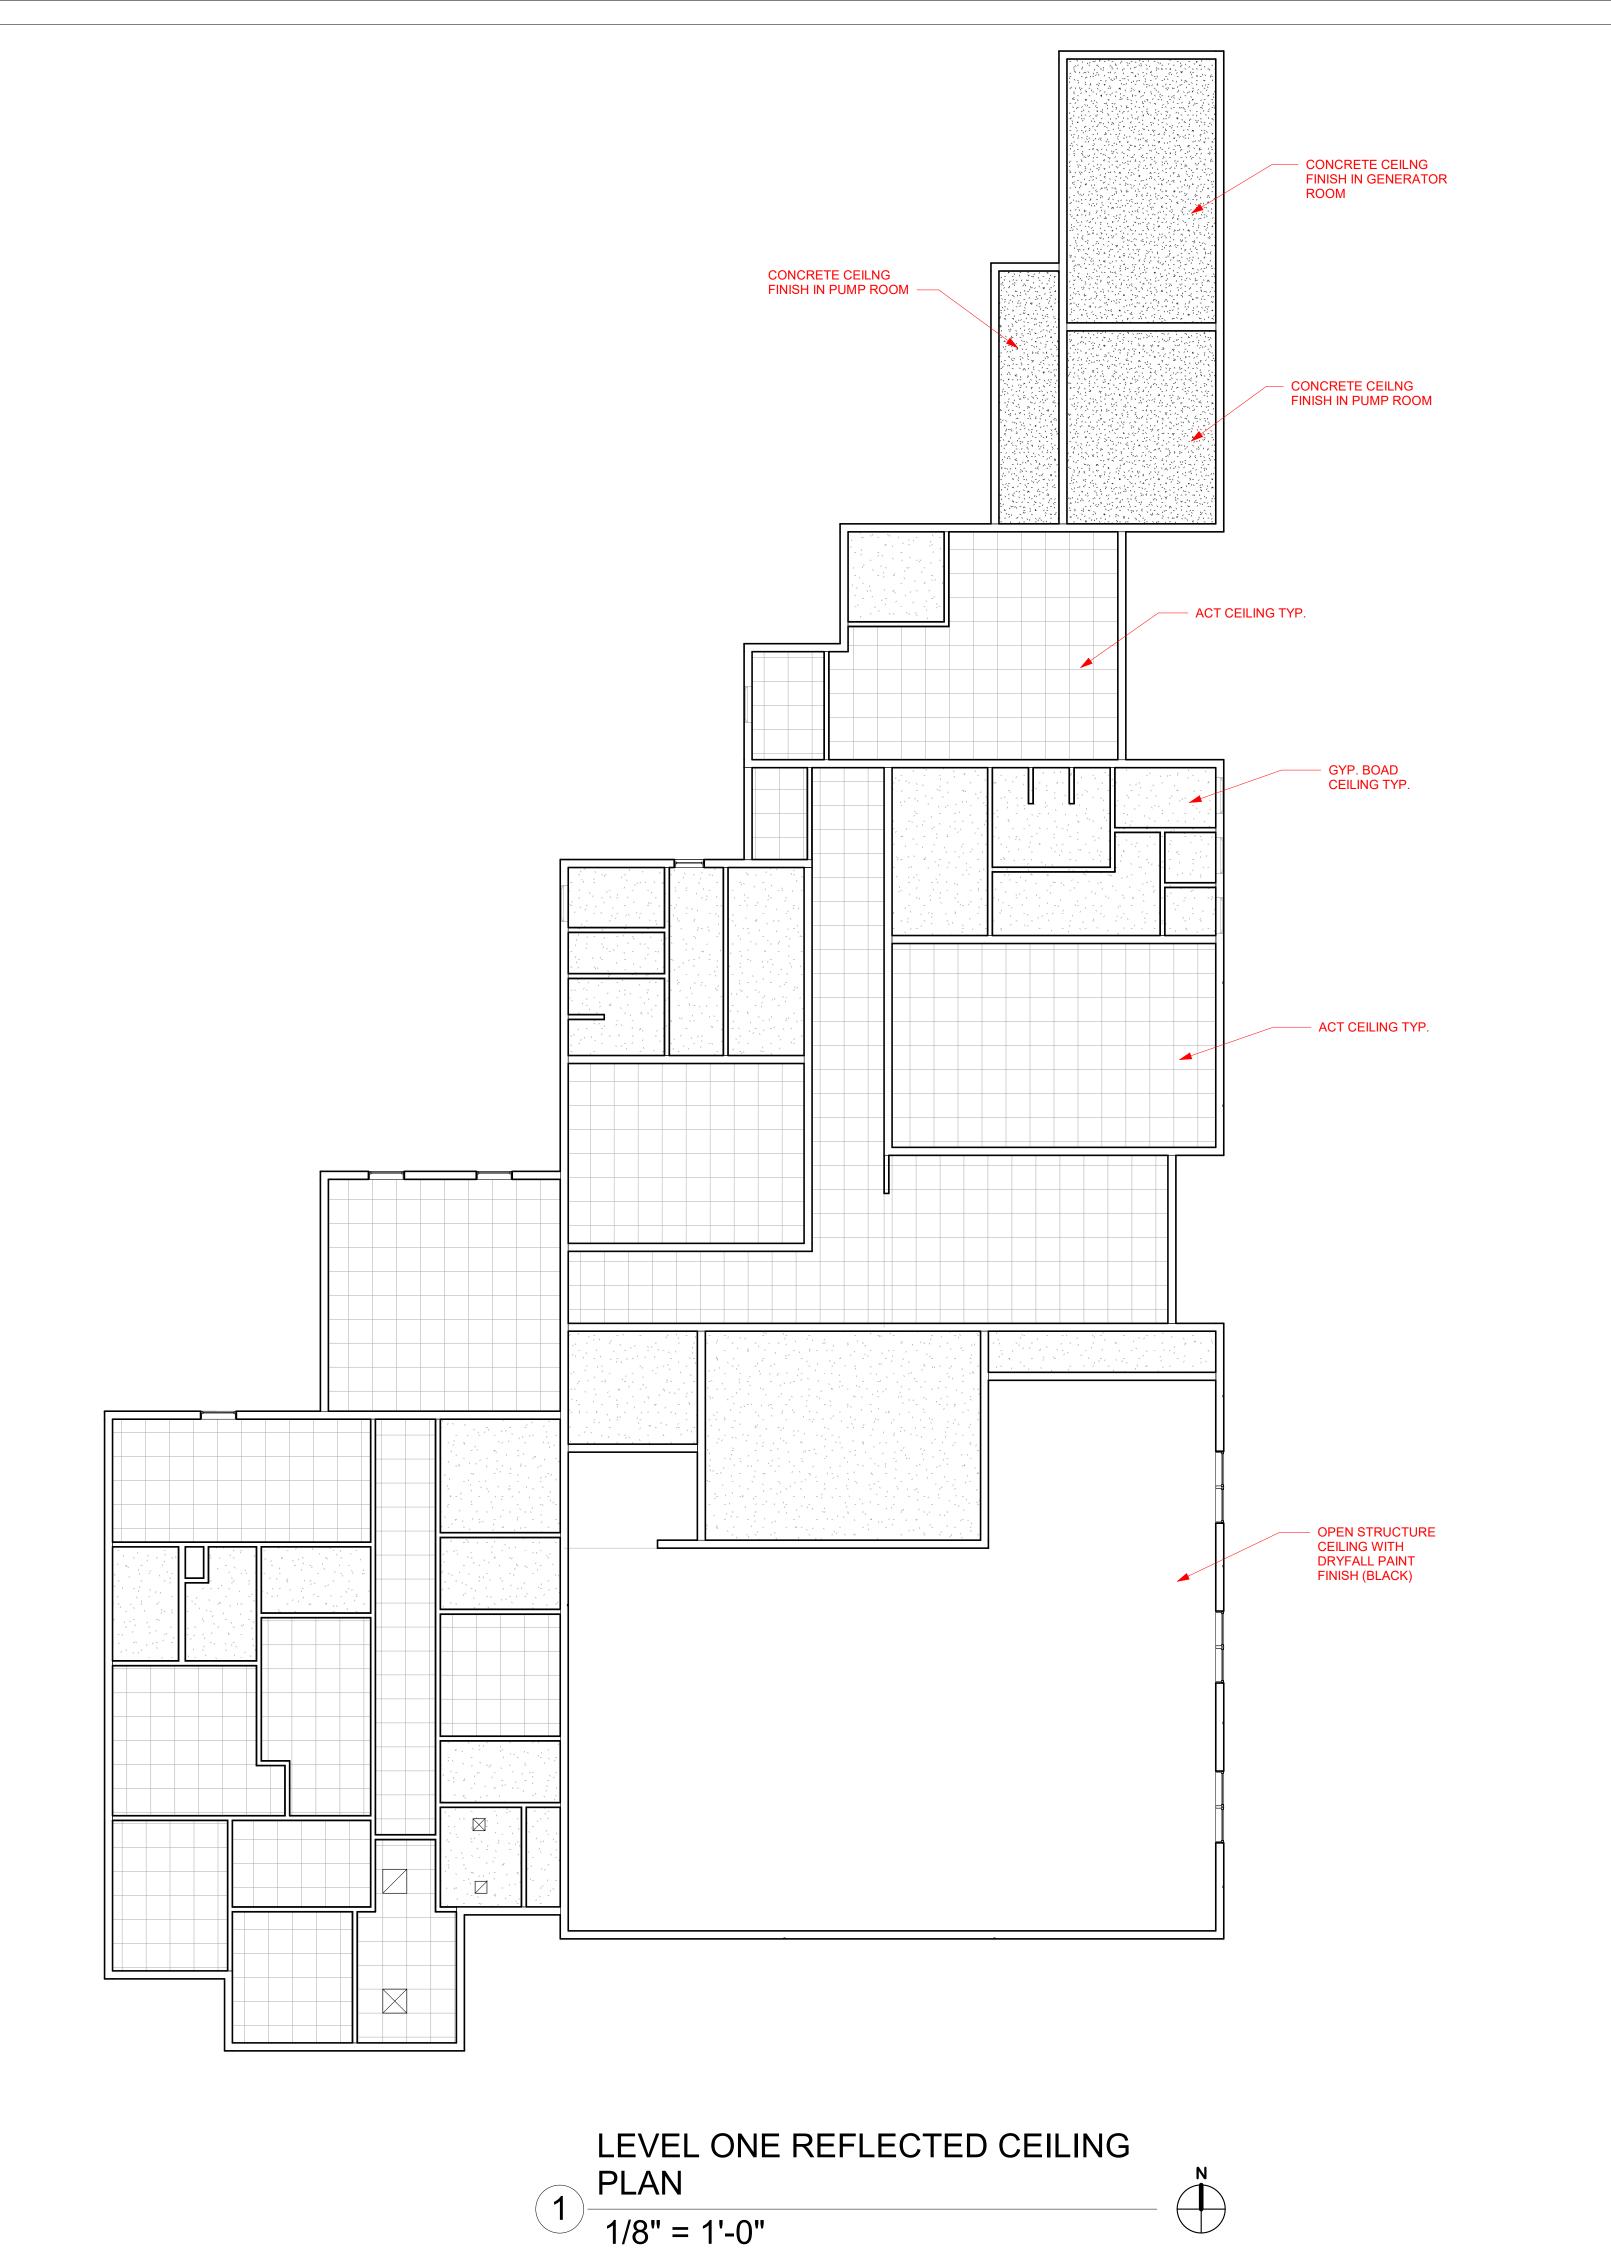

REFLECTED CEILING PLAN LEGEND

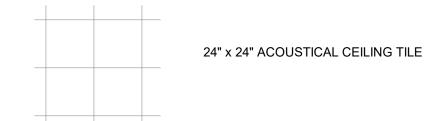




  









SEE ELECTRICAL DWGS. FOR LIGHTING LAYOUT





PRIME ARCHITECT

JAREDIAN DESIGN GROUP

5143 PALM PASSAGE, SECOND FLOOR - SUITES B24-25 ST. THOMAS, USVI 00802

PHONE: 340-777-1600

EMAIL: jarediandesigngroup@gmail.com

CONSULTING ARCHITECT

BOSCHULTE ARCHITECTURE, LLC

PO Box 303190 St. Thomas, VI 00803 phone: (340) 777-2375

phone: (340) 777-2375 e-mail: info@boschulte.com website: www.boschulte.com



FIRE STATION
LIMA COMPANY
390 ESTATE ANNAS RETREA
ST. THOMAS, U.S.V.I.

PROGRESS SET

No. Description Date

REVISIONS

No. Description Date

Project number 2021.007.04

Date 4/15/2025


Drawn by JTB

Checked by JTB

REFLECTED CEILING PLAN

A103

Scale:

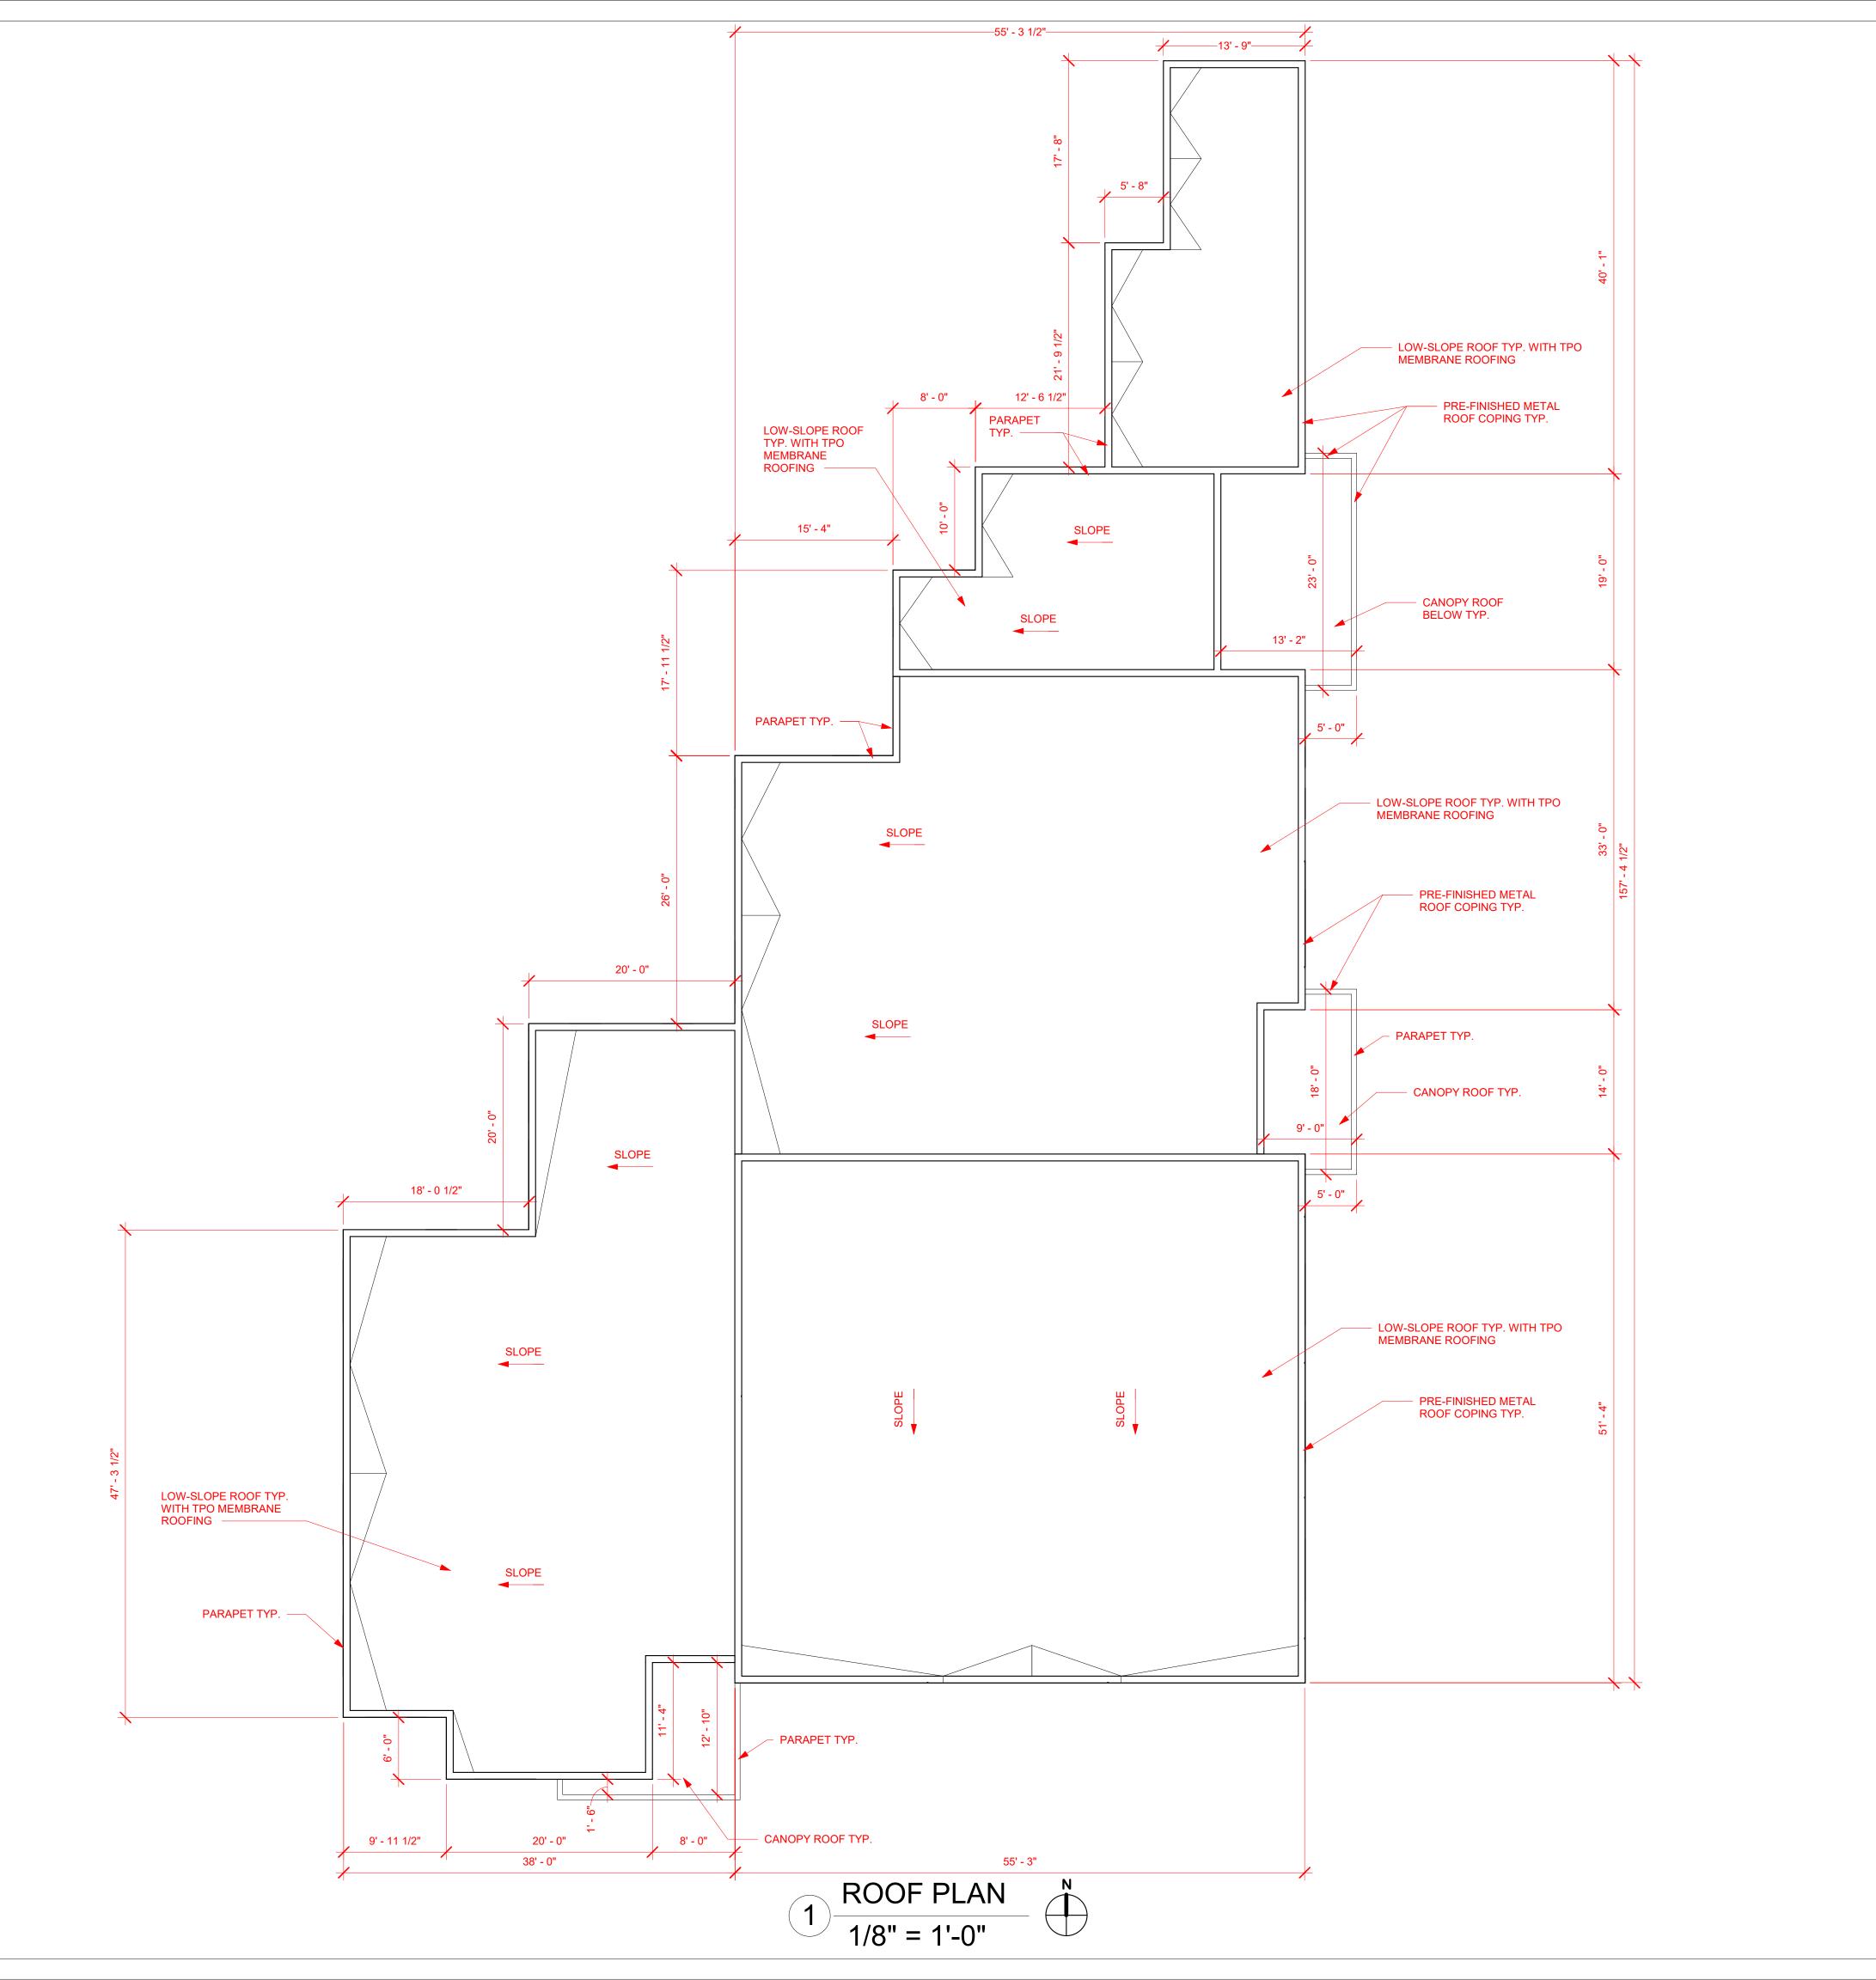





JAREDIAN DESIGN GROUP

5143 PALM PASSAGE, SECOND FLOOR - SUITES B24-25 ST. THOMAS, USVI 00802

PHONE: 340-777-1600

EMAIL: jarediandesigngroup@gmail.com

CONSULTING ARCHITECT

BOSCHULTE ARCHITECTURE, LLC
PO Box 303190
St. Thomas, VI 00803

St. Thomas, VI 00803

phone: (340) 777-2375
e-mail: info@boschulte.com
website: www.boschulte.com



FIRE STATION
LIMA COMPANY
390 ESTATE ANNAS RETRE/
ST. THOMAS, U.S.V.I.

	390				
PR	OGRESS SET				
No.	Description		Date		
RE	VISIONS				
No.	Descrip	tion	Date		
Pro	ject number	2021.0	07.04		
Da	te	4/15	/2025		
Dra	awn by		JTB		


ROOF PLAN

JTB

A104

cale: AS SHOWN

Checked by

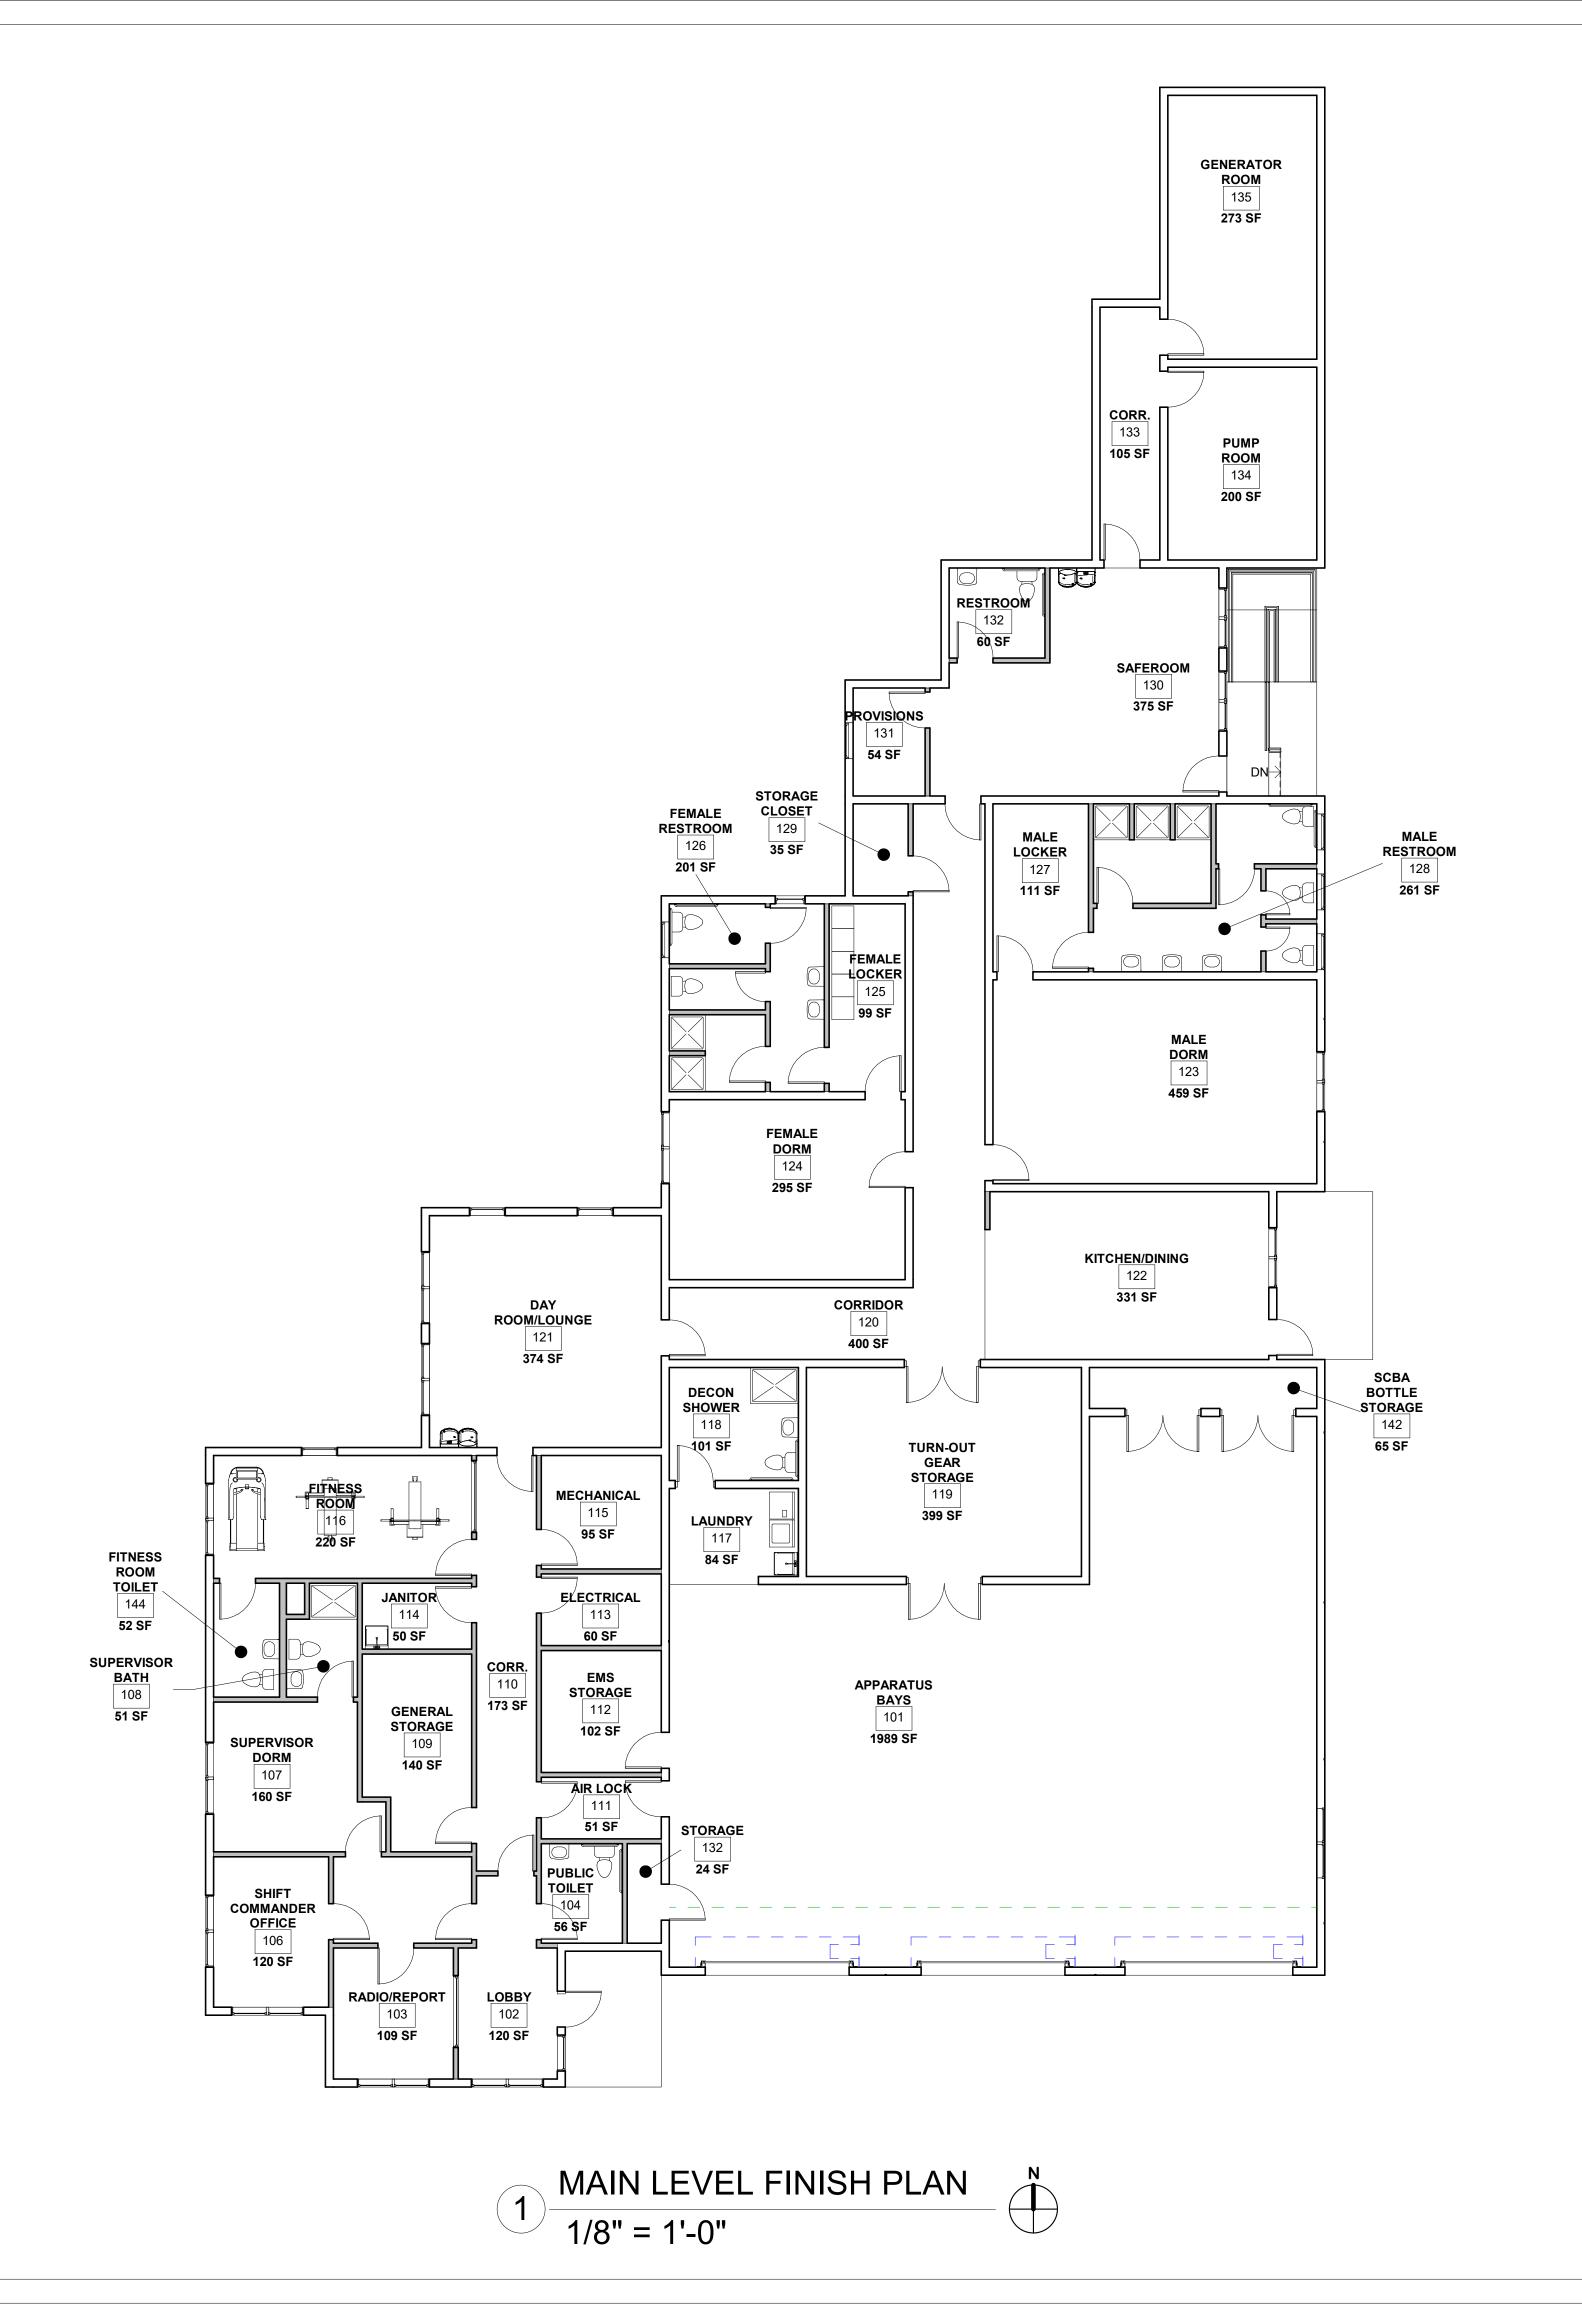





JAREDIAN DESIGN GROUP

5143 PALM PASSAGE, SECOND FLOOR - SUITES B24-25 ST. THOMAS, USVI 00802

PHONE: 340-777-1600

CONSULTING ARCHITECT

EMAIL: jarediandesigngroup@gmail.com

BOSCHULTE ARCHITECTURE, LLC

PO Box 303190 St. Thomas, VI 00803

phone: (340) 777-2375 e-mail: info@boschulte.com website: www.boschulte.com



FIRE STATION
LIMA COMPANY
390 ESTATE ANNAS RETRE
ST. THOMAS, U.S.V.I.

PROGRESS SET

No. Description Date

REVISIONS

No. Description Date

Project number 2021.007.04

Date 4/15/2025

Drawn by JTB


Checked by JTB

FINISH PLAN

A105

AS SHOWN

Scale:

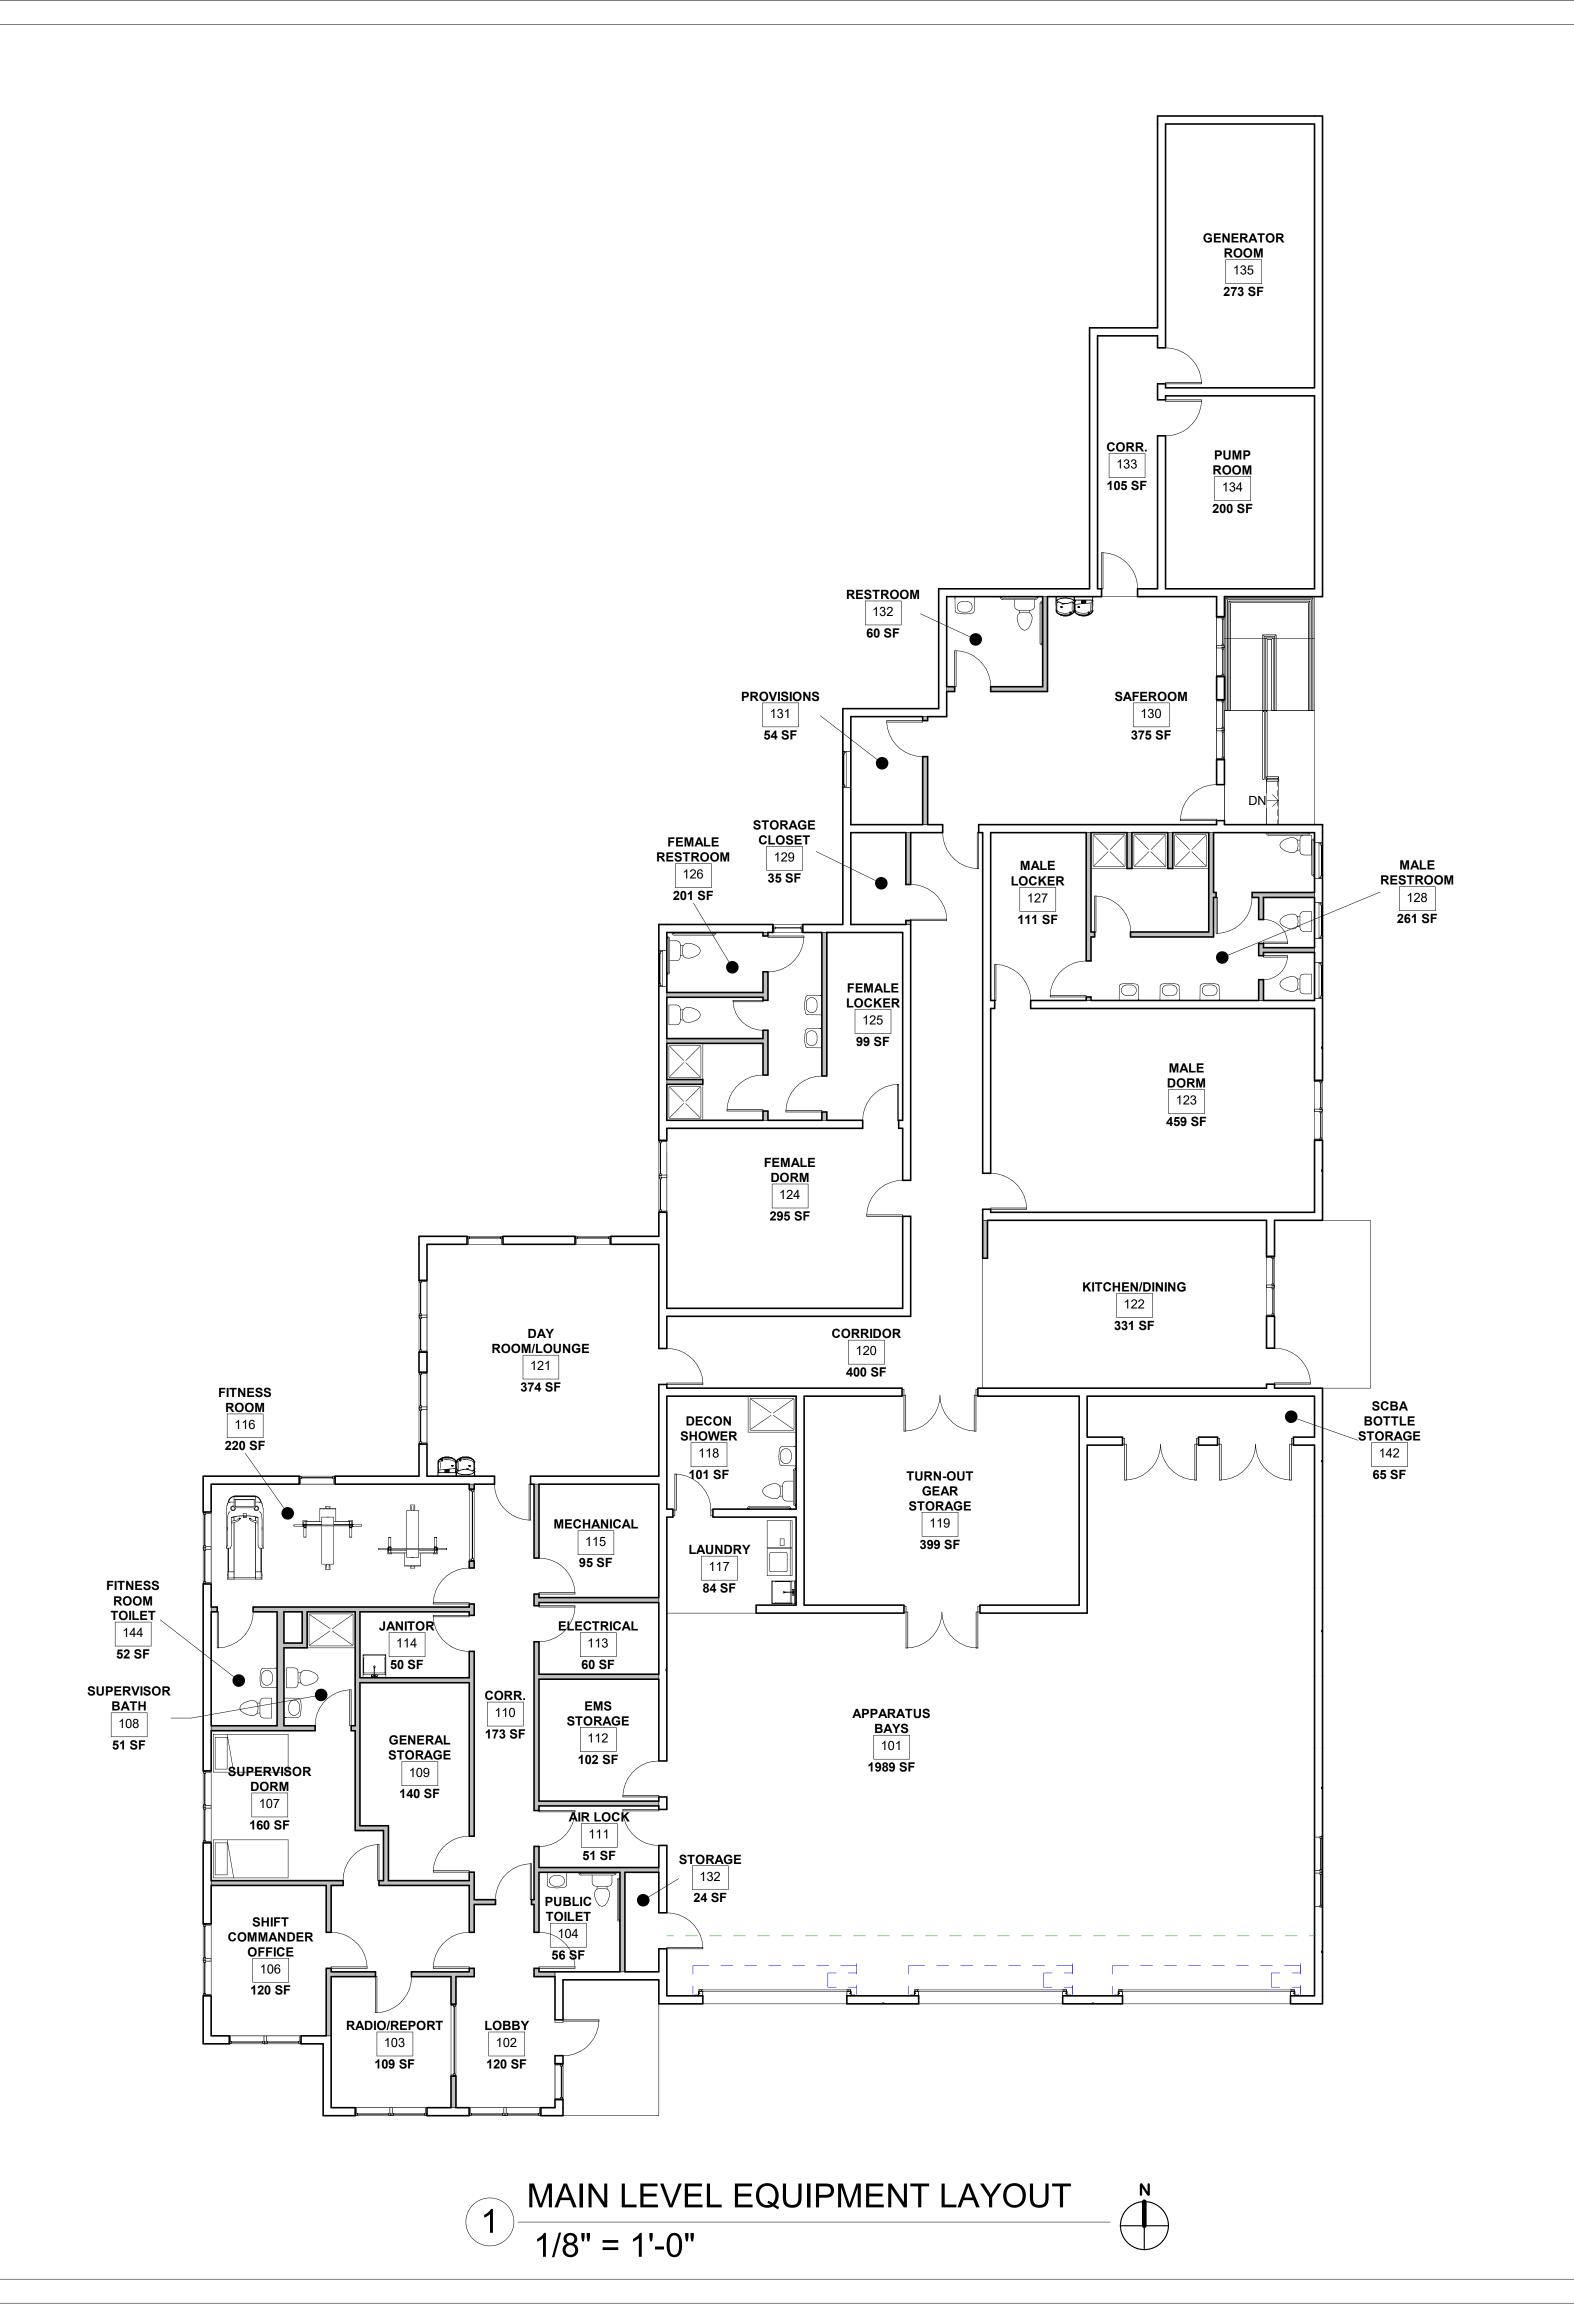





JAREDIAN DESIGN GROUP

5143 PALM PASSAGE, SECOND FLOOR - SUITES B24-25 ST. THOMAS, USVI 00802

PHONE: 340-777-1600

EMAIL: jarediandesigngroup@gmail.com CONSULTING ARCHITECT

BOSCHULTE ARCHITECTURE, LLC

PO Box 303190 St. Thomas, VI 00803

phone: (340) 777-2375 e-mail: info@boschulte.com website: www.boschulte.com




90

		36	
PR	OGRESS SET		
No.	Description	on	Date
RE	VISIONS		
No.	Description	Description	
Pro	ject number	2021.0	07.04
Da	te	4/15	/2025
Dra	awn by		JTB
Ch	ecked by		JTB

EQUIPMENT LAYOUT PLAN

A106

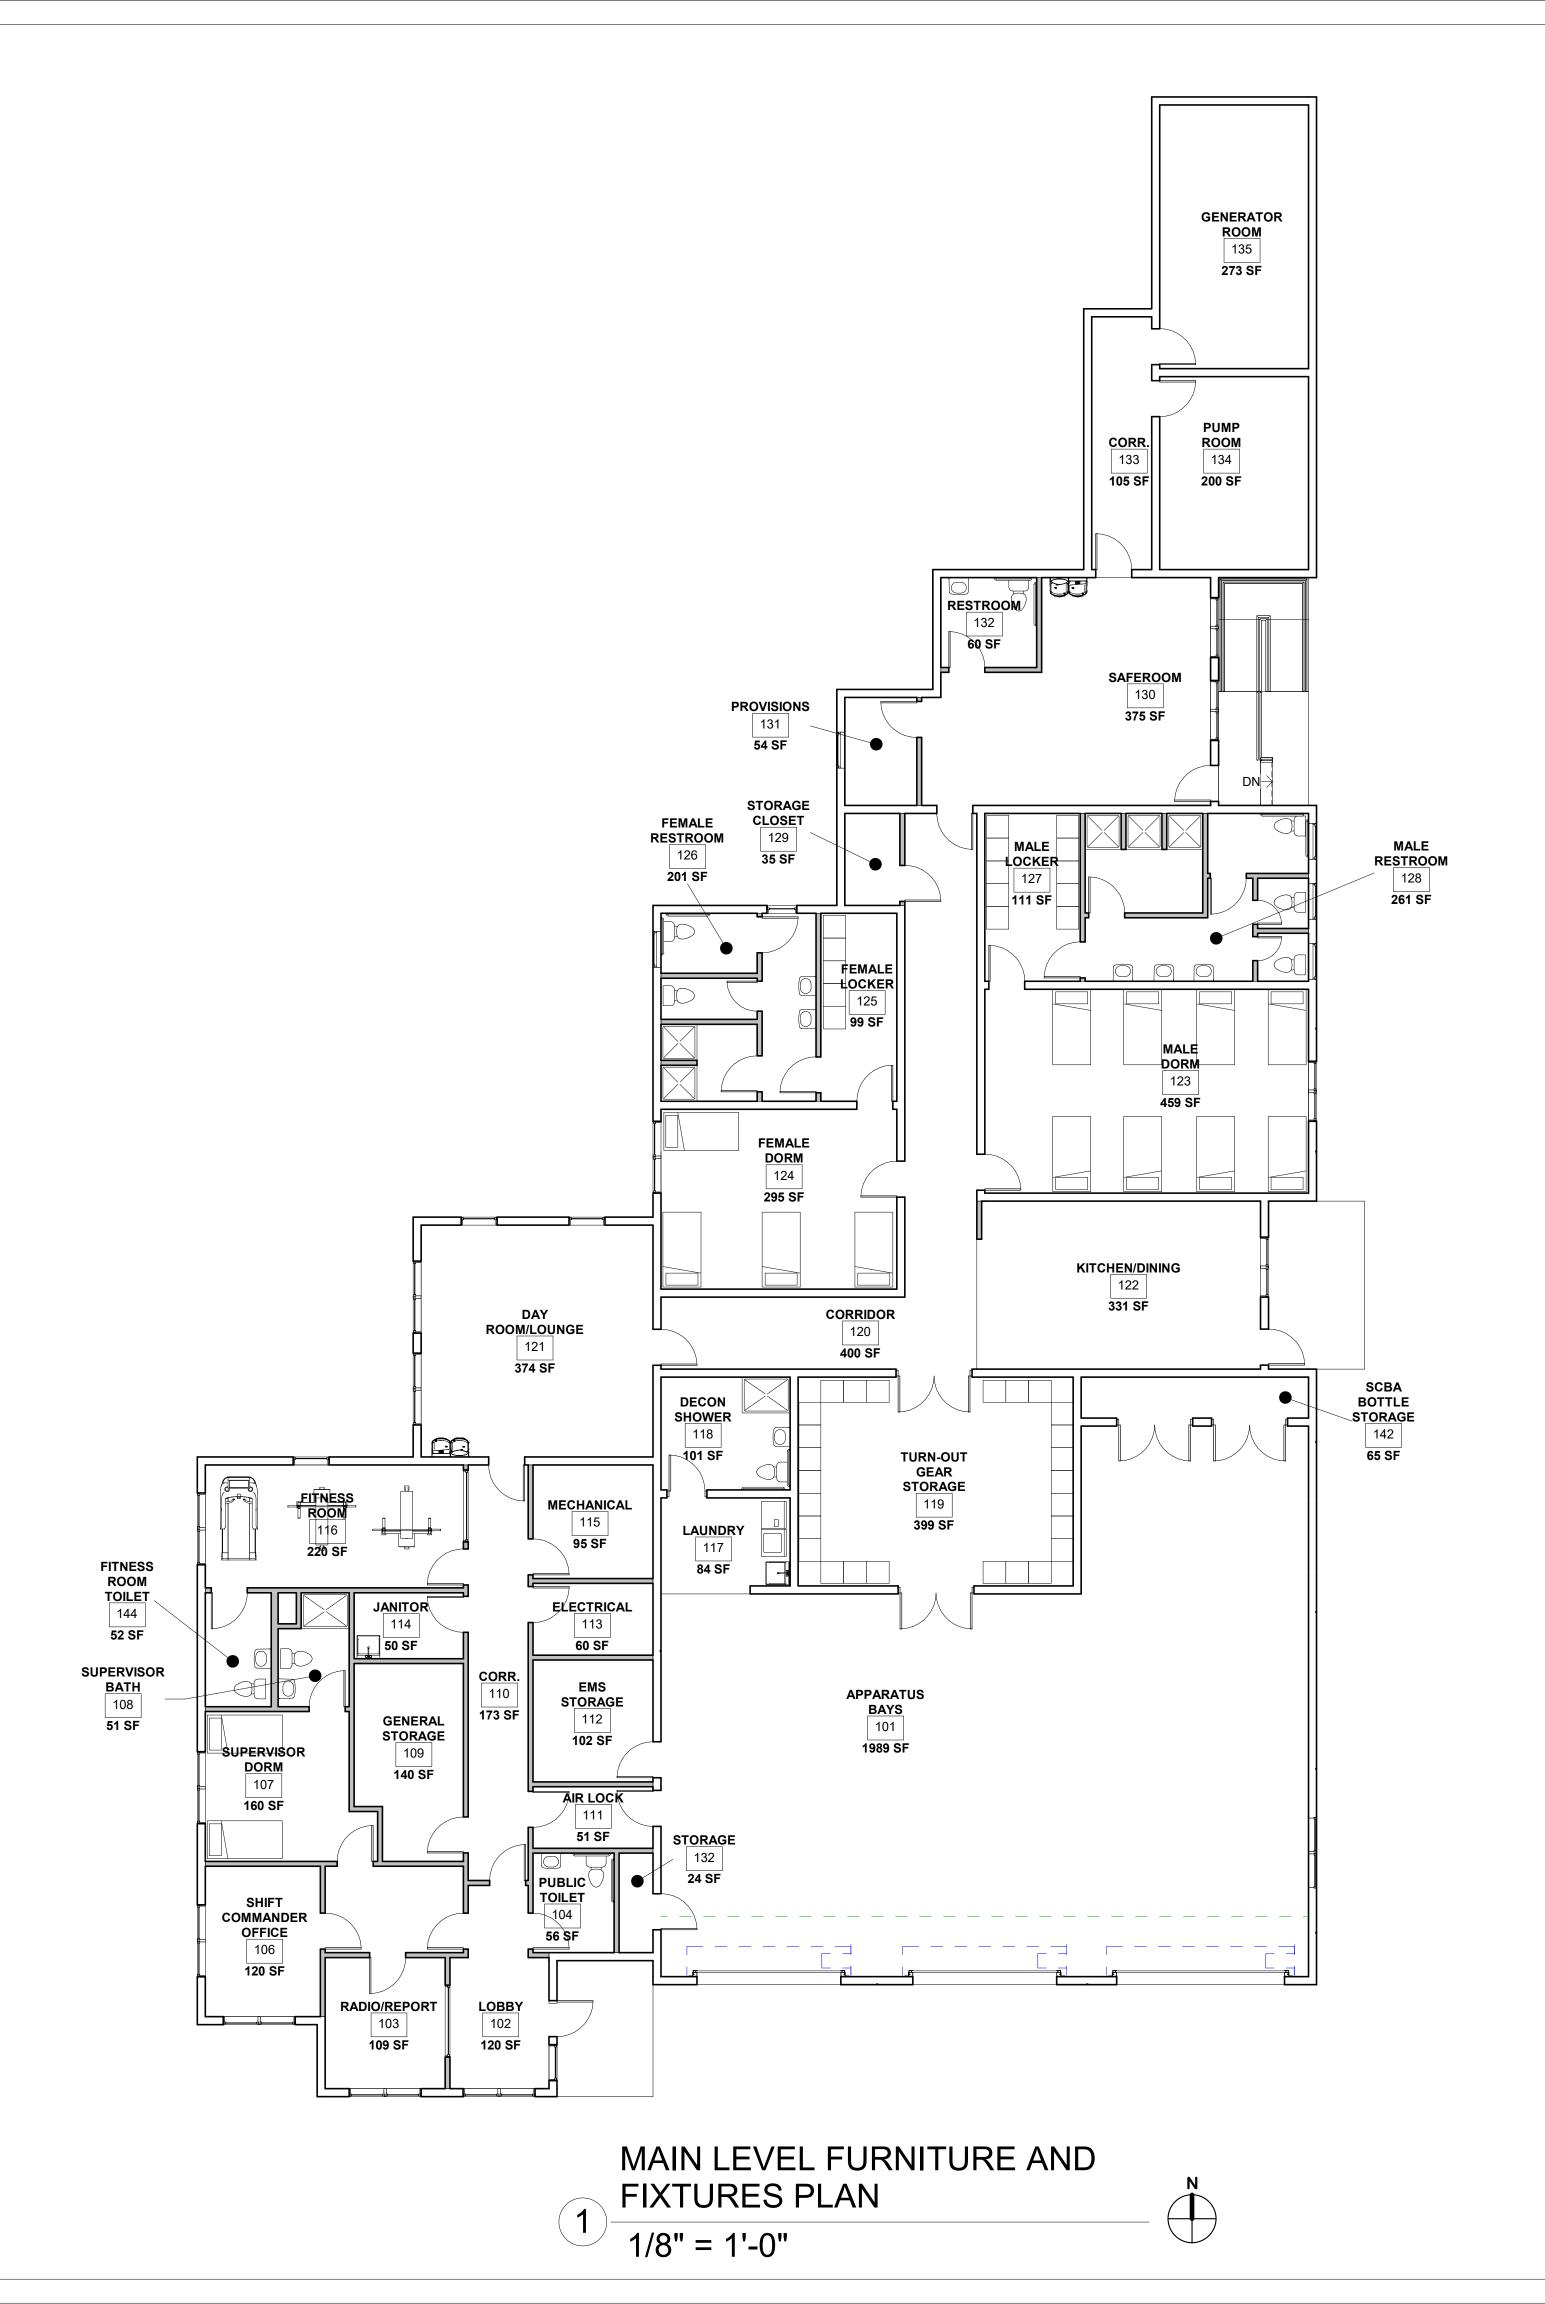





JAREDIAN DESIGN GROUP

5143 PALM PASSAGE, SECOND FLOOR - SUITES B24-25 ST. THOMAS, USVI 00802

PHONE: 340-777-1600

CONSULTING ARCHITECT

BOSCHULTE ARCHITECTURE, LLC

EMAIL: jarediandesigngroup@gmail.com

PO Box 303190 St. Thomas, VI 00803


phone: (340) 777-2375 e-mail: info@boschulte.com website: www.boschulte.com




		(7)	
PR	OGRESS SET		
No.	Descriptio	n	Date
RE	VISIONS		
No.	Descriptio	n	Date
Pro	ject number	2021.0	07.04
Da	te	4/15	/2025
Dra	awn by		JTB
Ch	ecked by		JTB

FURNITURE AND FIXTURES
PLAN


A107

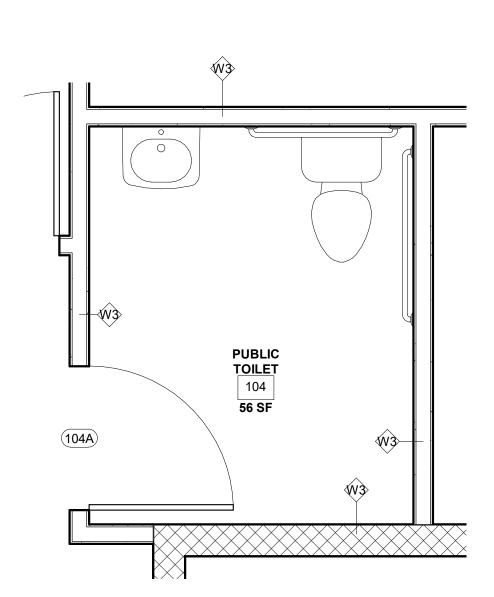

PUBLIC TOILET 104 ENLARGED

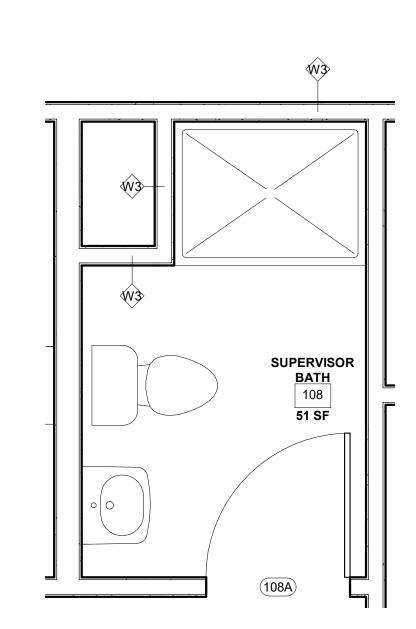


SUPERVISOR BATH 108 ENLARGED

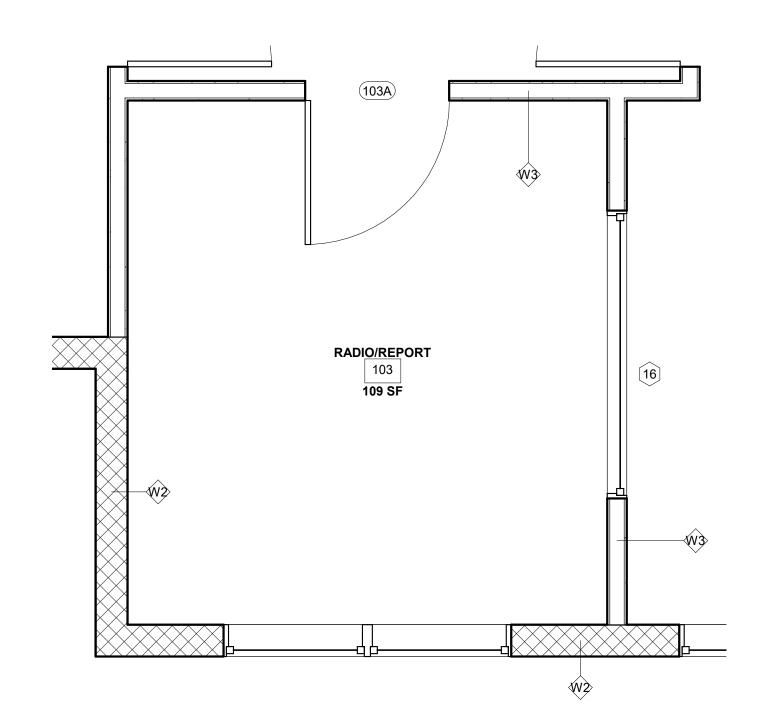


RADIO/REPORT 109 ENLARGED




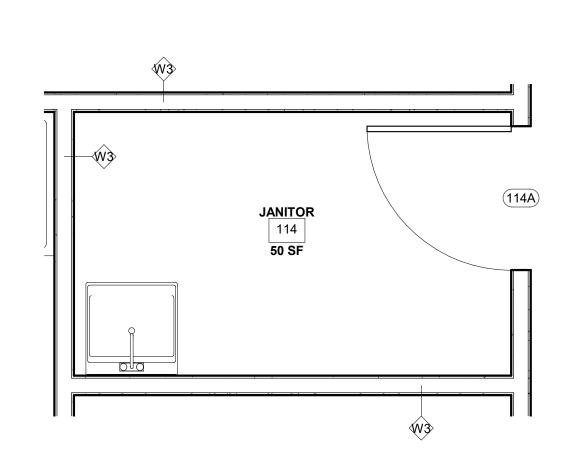

JANITOR 114 ENLARGED PLAN 1/2" = 1'-0"

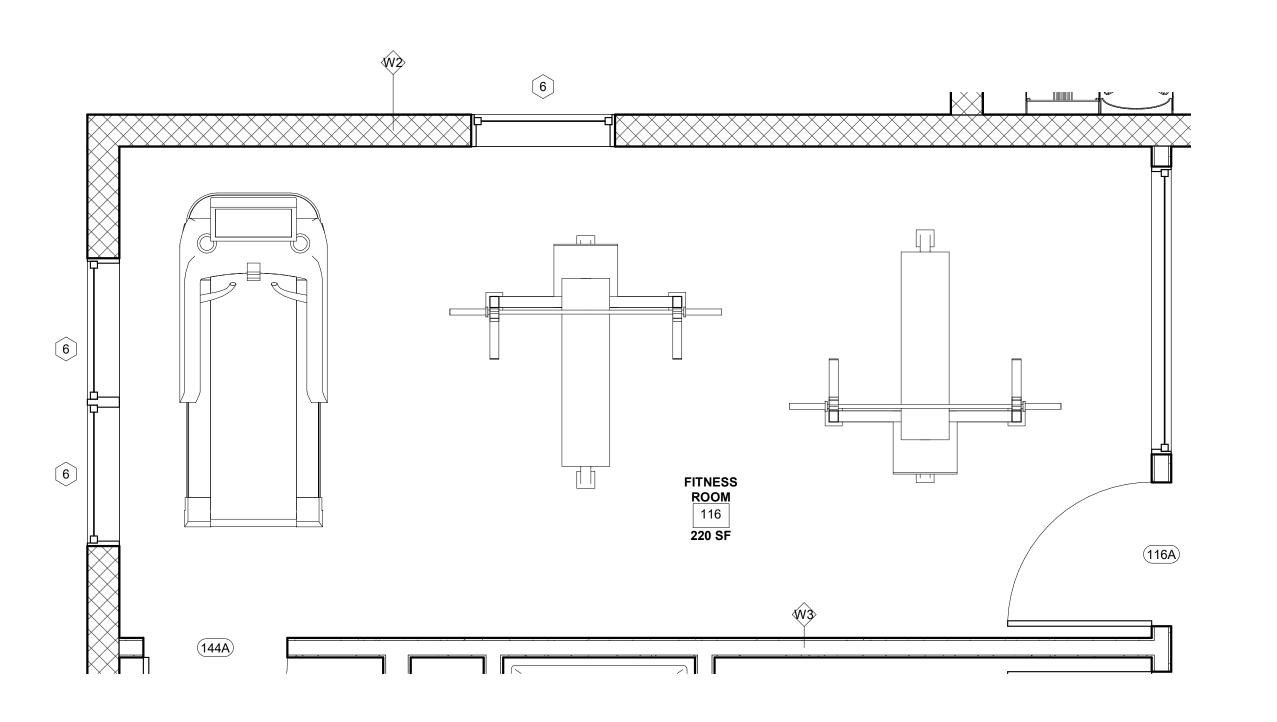

FITNESS ROOM 116 ENLARGED PLAN 1/2" = 1'-0"

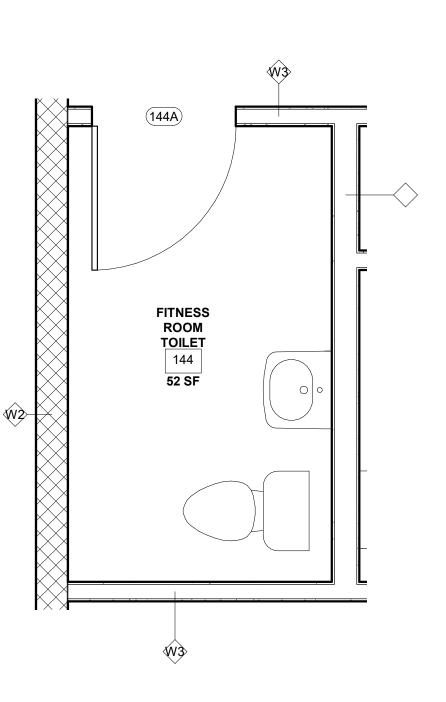

FITNESS ROOM TOILET 144 ENLARGED PLAN 1/2" = 1'-0"



BOSCHULTE ARCHITECTURE

PRIME ARCHITECT

JAREDIAN DESIGN GROUP

5143 PALM PASSAGE, SECOND FLOOR - SUITES B24-25 ST. THOMAS, USVI 00802

EMAIL: jarediandesigngroup@gmail.com

CONSULTING ARCHITECT BOSCHULTE ARCHITECTURE, LLC

PO Box 303190 St. Thomas, VI 00803


phone: (340) 777-2375 e-mail: info@boschulte.com website: www.boschulte.com





	C	
PR	OGRESS SET	
No.	Description	Date
1	SCHEMATIC DESIGN	04/06/202
2	SCHEMATIC DESIGN	04/21/202
3	DESIGN DEVELOPMENT	06/06/202
4	CONSTRUCTION DOCUMENTS 50%	08/22/202
RE No.	VISIONS Description	Date
140.	Description	Date
Pro	oject number 2021.	.007.04
Da	te 4/1	5/2025
Dra	awn by	JTB
Ch	ecked by	ITD

ENLARGED FLOOR PLANS

A150

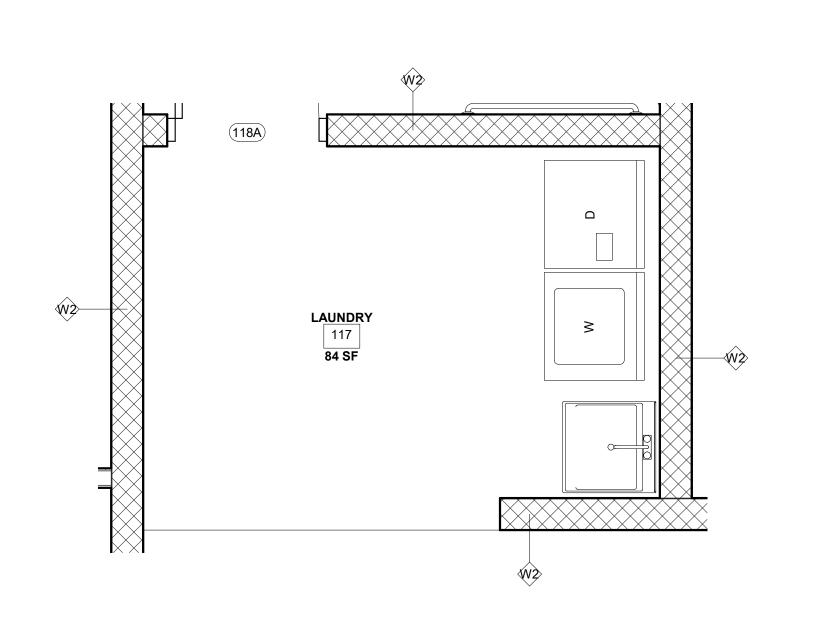

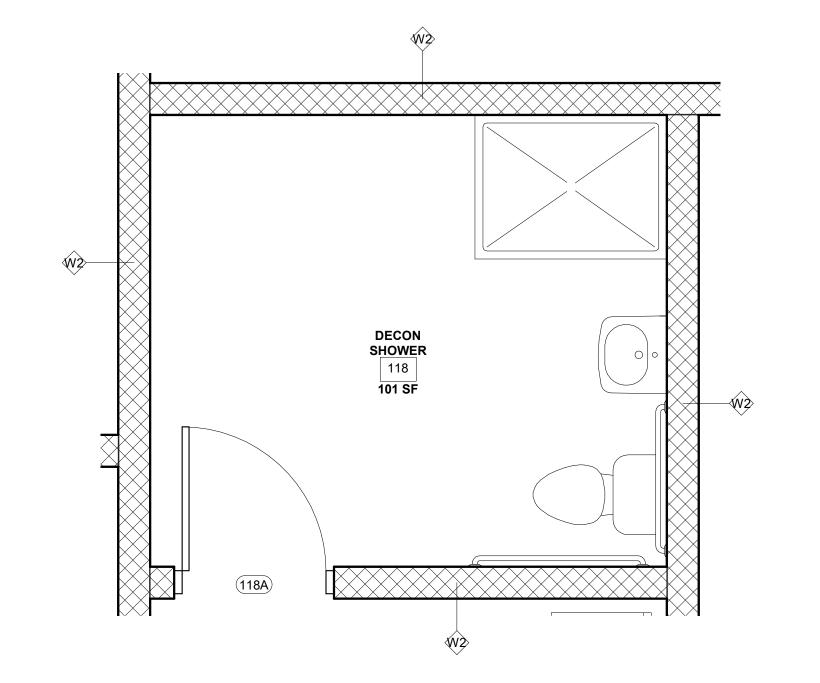

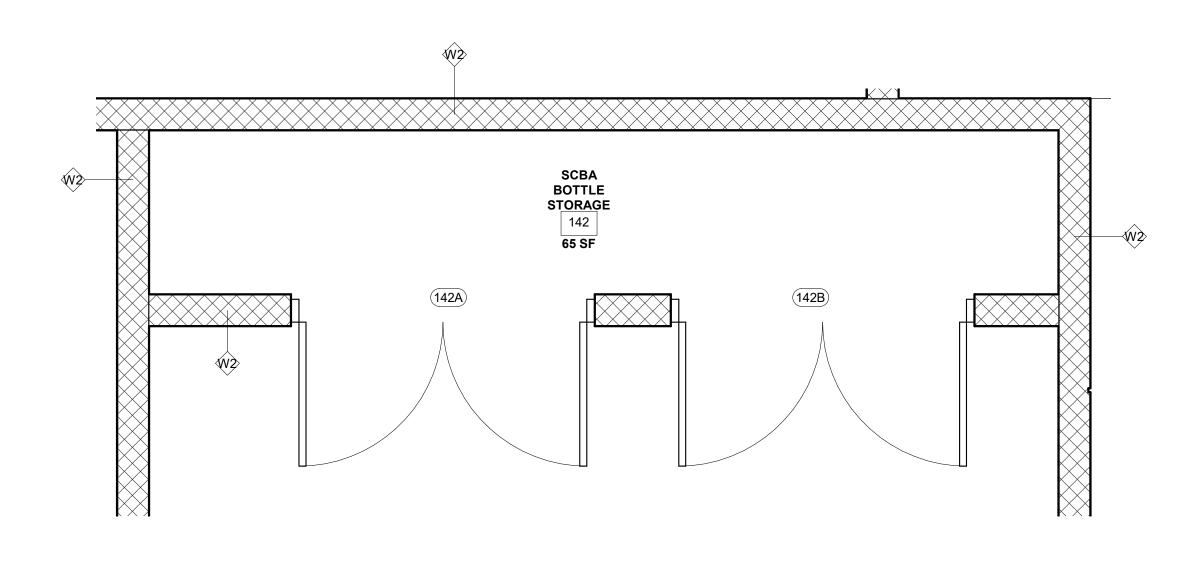

1 LAUNDRY 117 ENLARGED PLAN 1/2" = 1'-0"


DECON SHOWER 118 ENLARGED

PLAN


1/2" = 1'-0"

SCBA BOTTLE STORAGE 142
ENLARGED PLAN

1/2" = 1'-0"

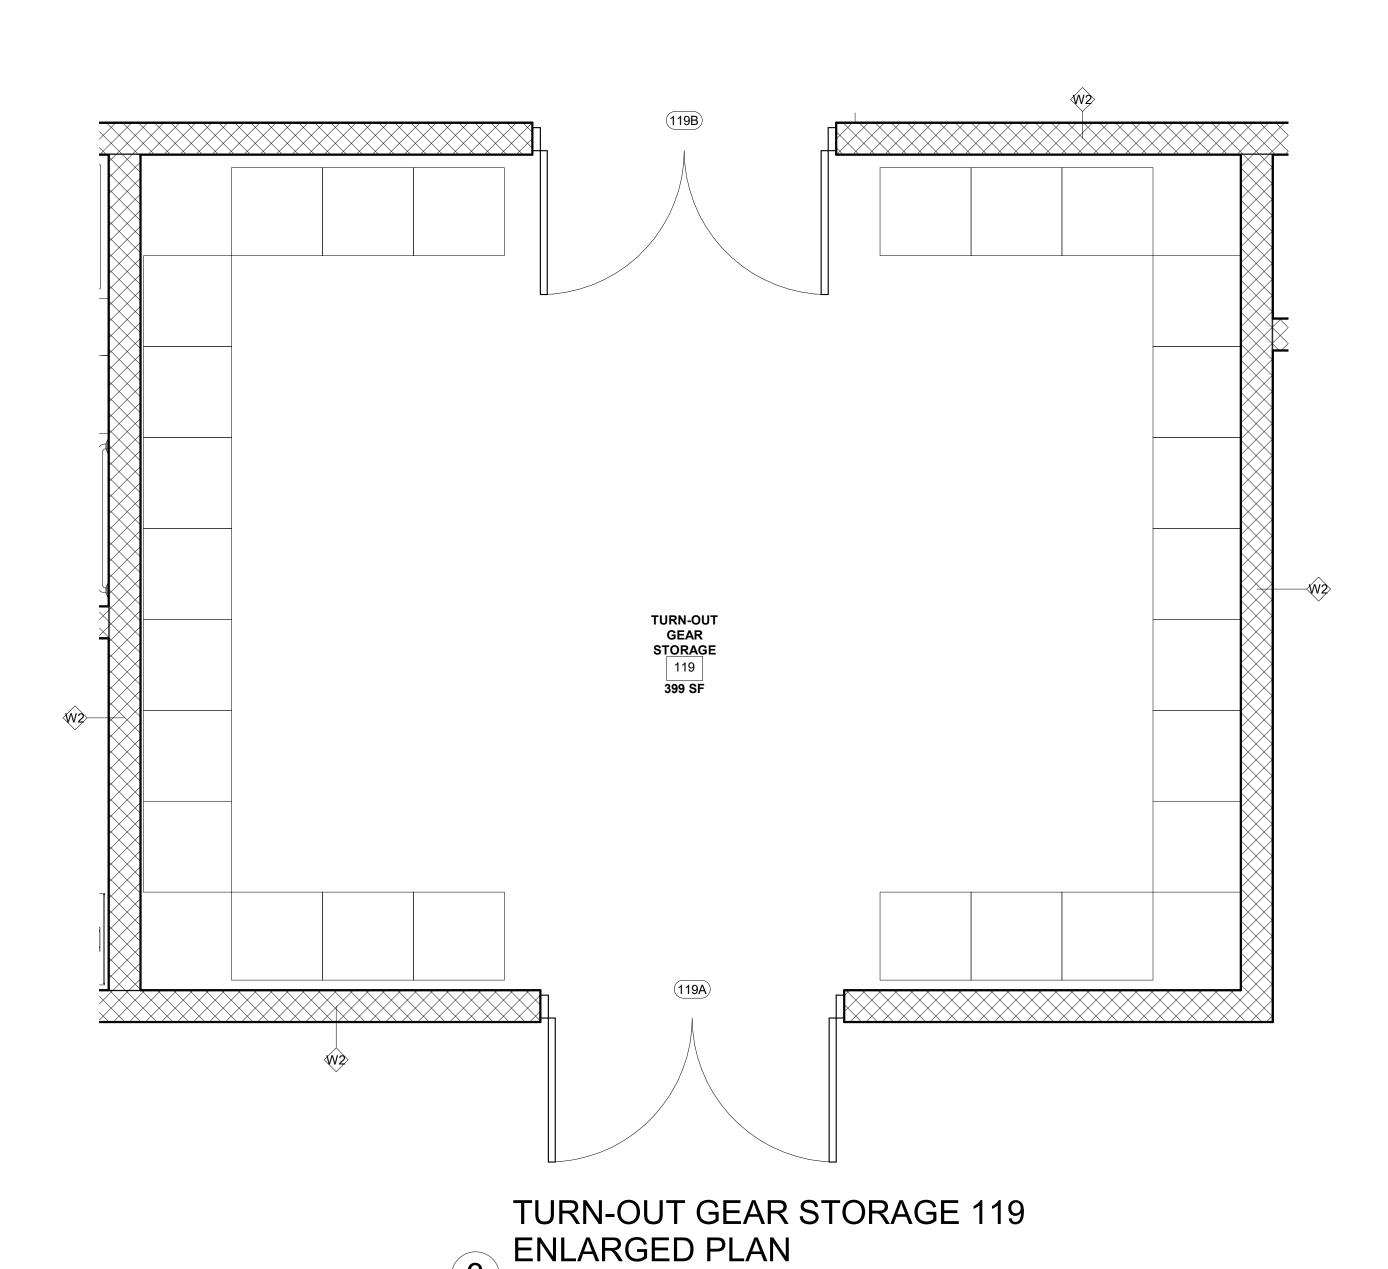

1/2" = 1'-0"

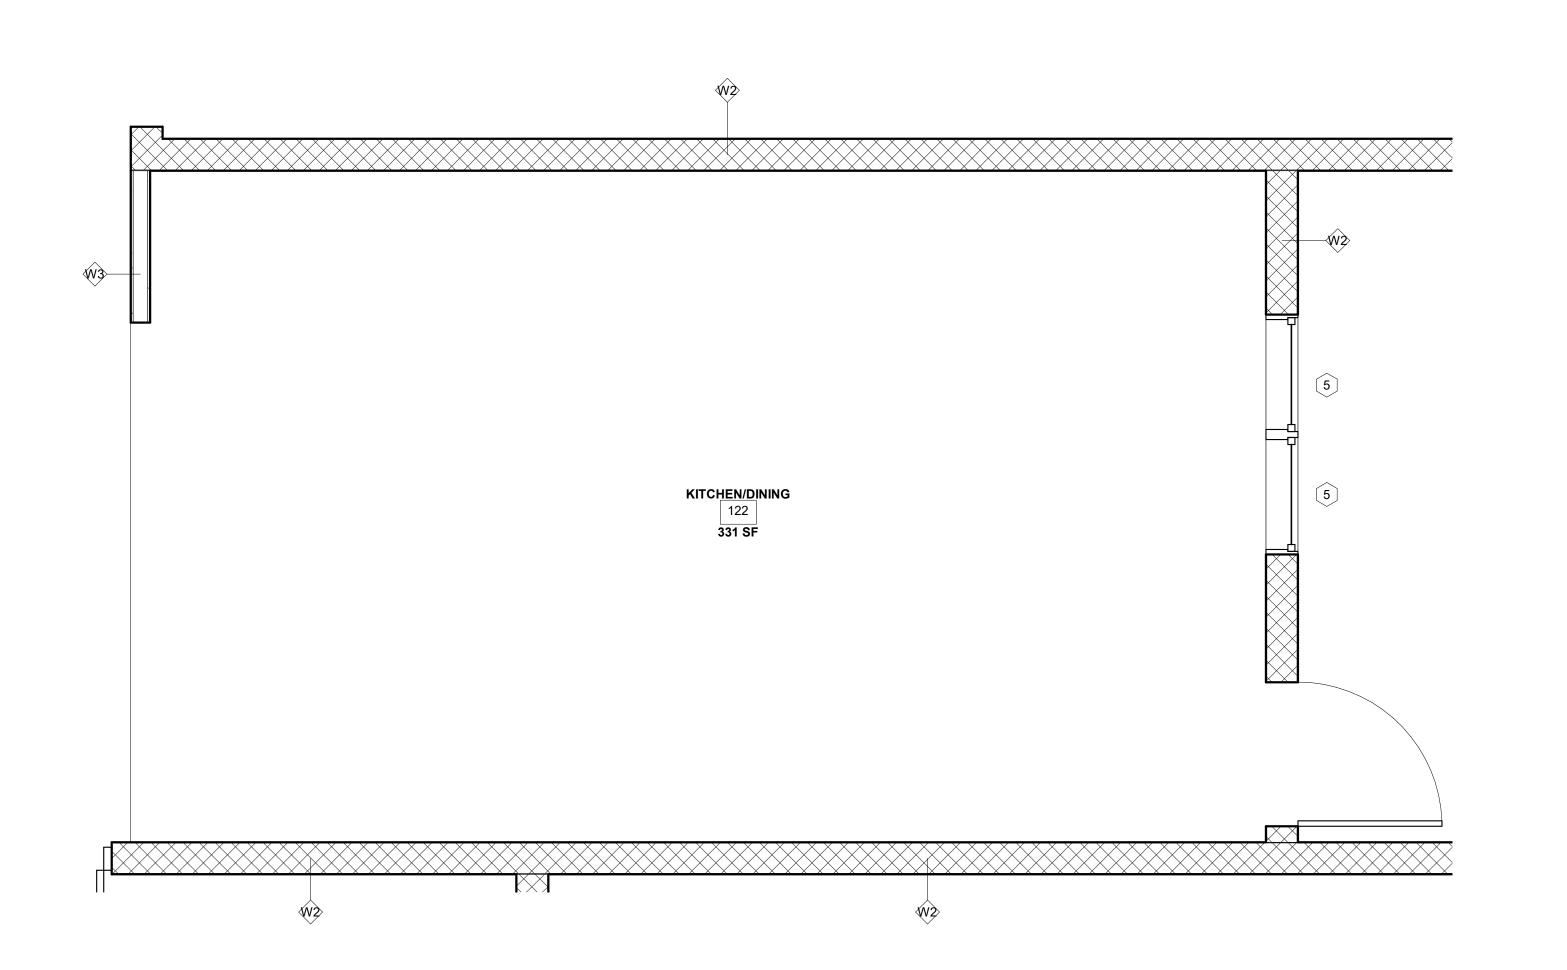

KITCHEN/DINING 122 ENLARGED

1/2" = 1'-0"





PRIME ARCHITECT

JAREDIAN DESIGN GROUP

5143 PALM PASSAGE, SECOND FLOOR - SUITES B24-25 ST. THOMAS, USVI 00802

HONE: 340-777-1600

CONSULTING ARCHITECT

BOSCHULTE ARCHITECTURE, LLC

PO Box 303190 St. Thomas, VI 00803

phone: (340) 777-2375 e-mail: info@boschulte.com website: www.boschulte.com

website. www.poschuite.com



GEORGE C. SCOTT
FIRE STATION
LIMA COMPANY
390 ESTATE ANNAS RETREA
ST. THOMAS, U.S.V.I.

PROGRESS SET

No. Description Date

REVISIONS

No. Description Date

Project number 2021.007.04

Date 4/15/2025


Drawn by JTB

Checked by JTB


ENLARGED PLANS

A151


e: AS SH

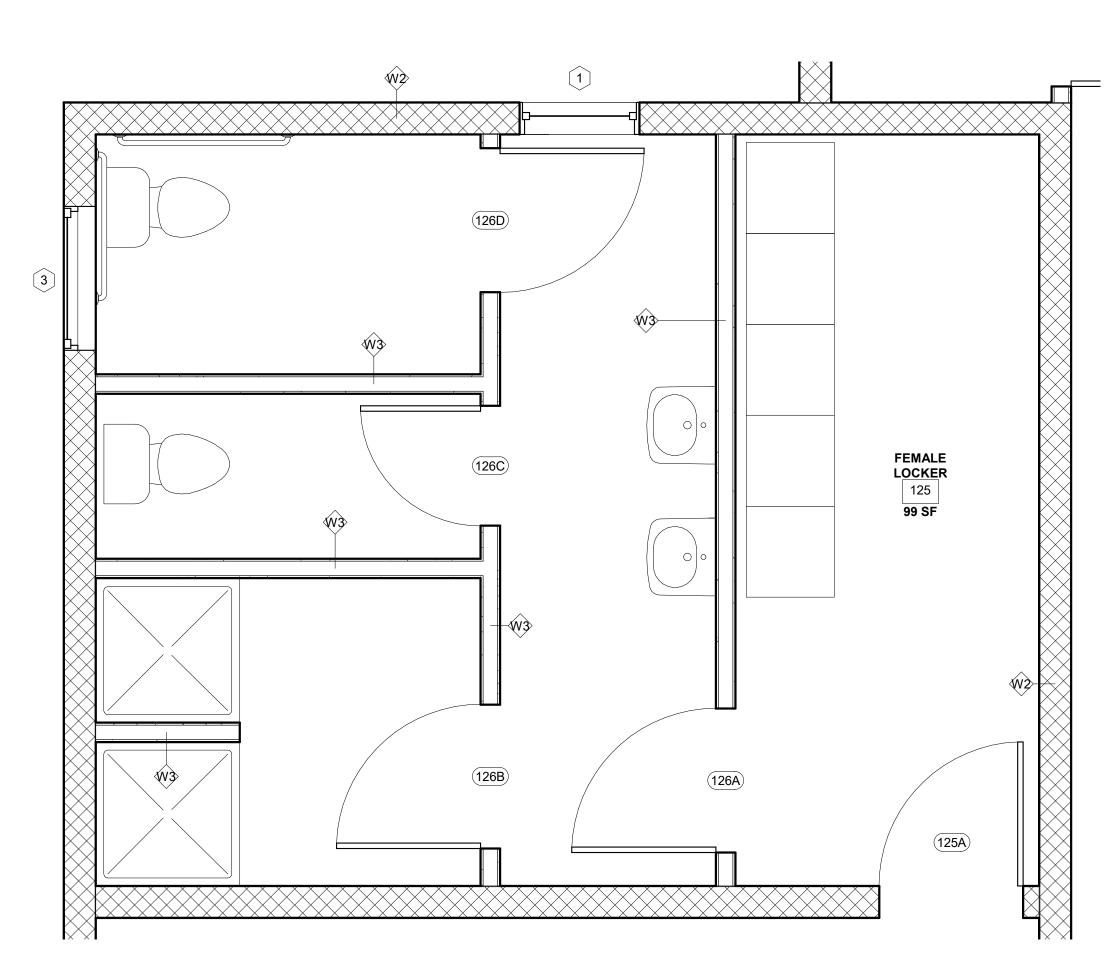



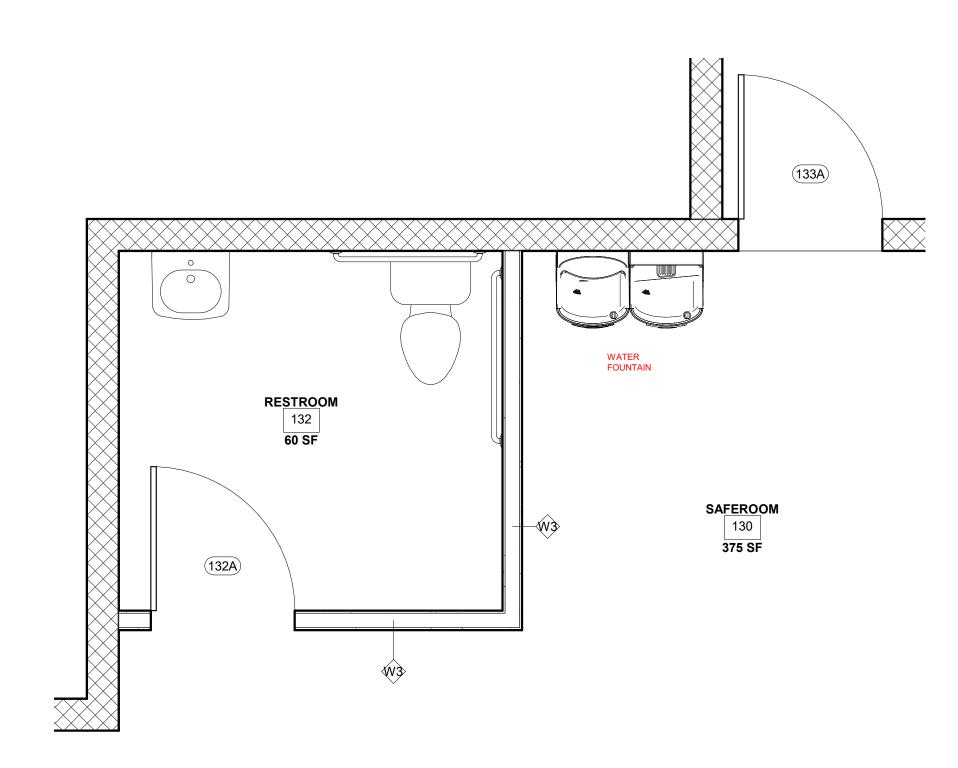

 $\frac{\text{RESTROOM 132 ENLARGED PLAN}}{1/2" = 1'-0"}$

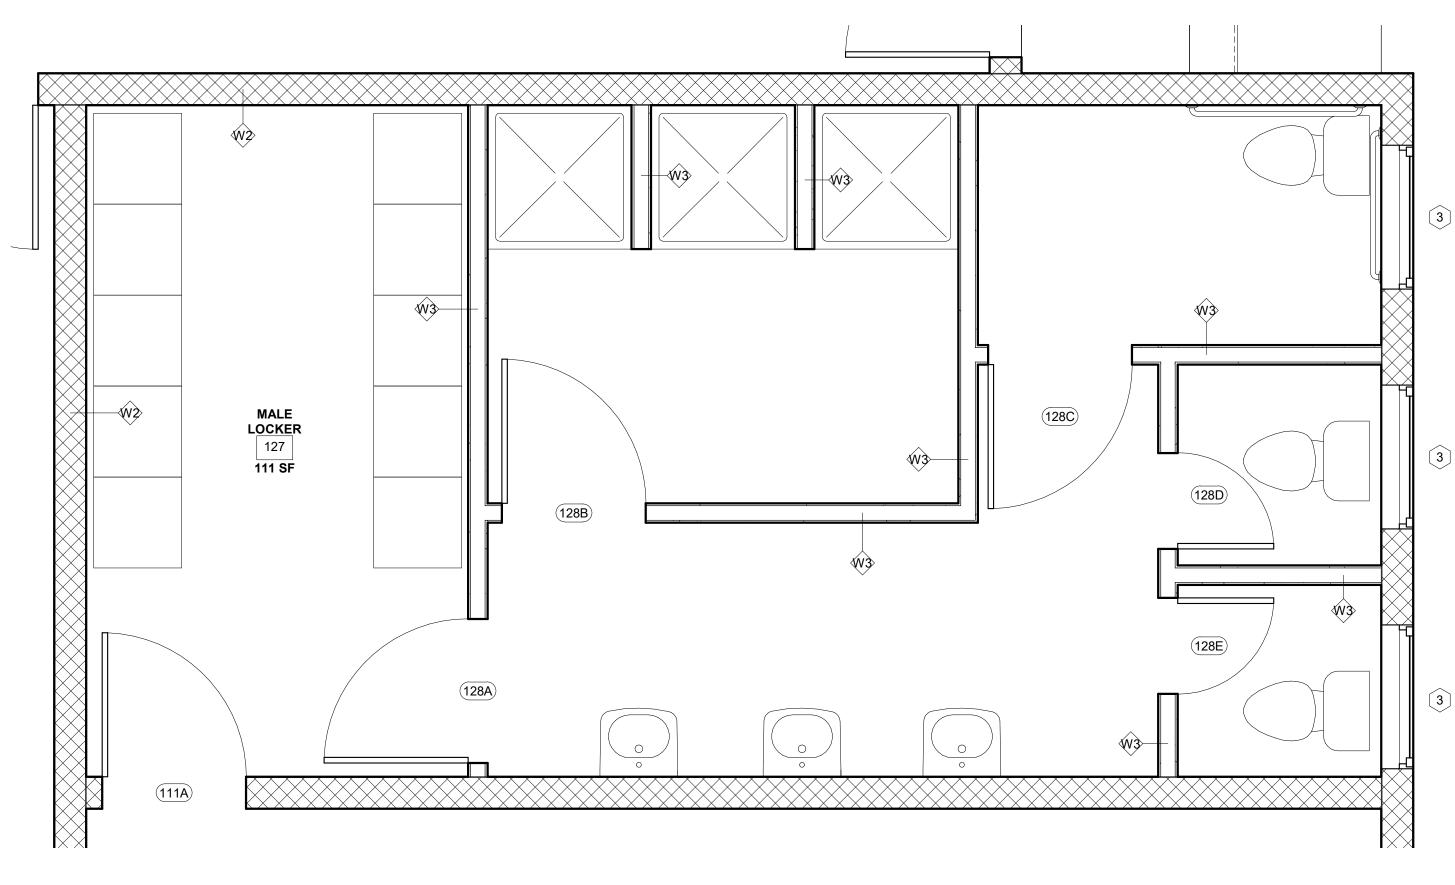



 $\frac{1}{2} \frac{\text{PLAN}}{1/2" = 1'-0"}$





PRIME ARCHITECT

JAREDIAN DESIGN GROUP

5143 PALM PASSAGE, SECOND FLOOR - SUITES B24-25 ST. THOMAS, USVI 00802

ONE: 340-777-1600

EMAIL: jarediandesigngroup@gmail.com

CONSULTING ARCHITECT

BOSCHULTE ARCHITECTURE, LLC

PO Box 303190 St. Thomas, VI 00803

phone: (340) 777-2375 e-mail: info@boschulte.com website: www.boschulte.com





FIRE STATION
LIMA COMPANY
390 ESTATE ANNAS RETRE
ST. THOMAS, U.S.V.I.

PROGRESS SET

No. Description Date

REVISIONS

No. Description Date

Project number 2021.007.04

Date 4/15/2025


Drawn by JTB

Checked by JTB


ENLARGED PLANS

A152

Scale:

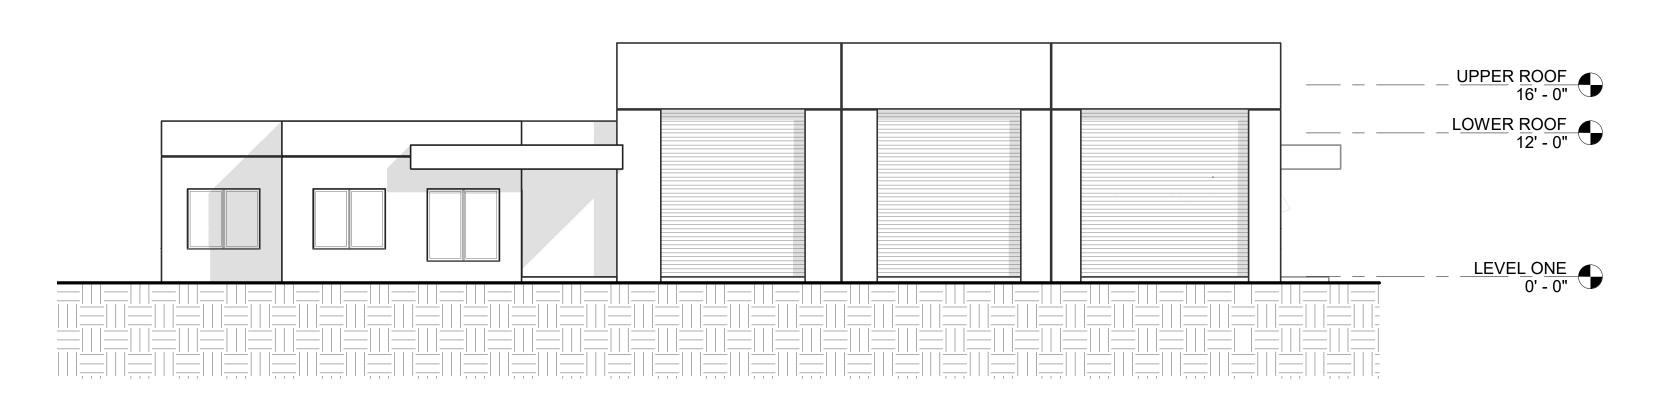

 $\frac{\text{SOUTH ELEVATION}}{1/8" = 1'-0"}$

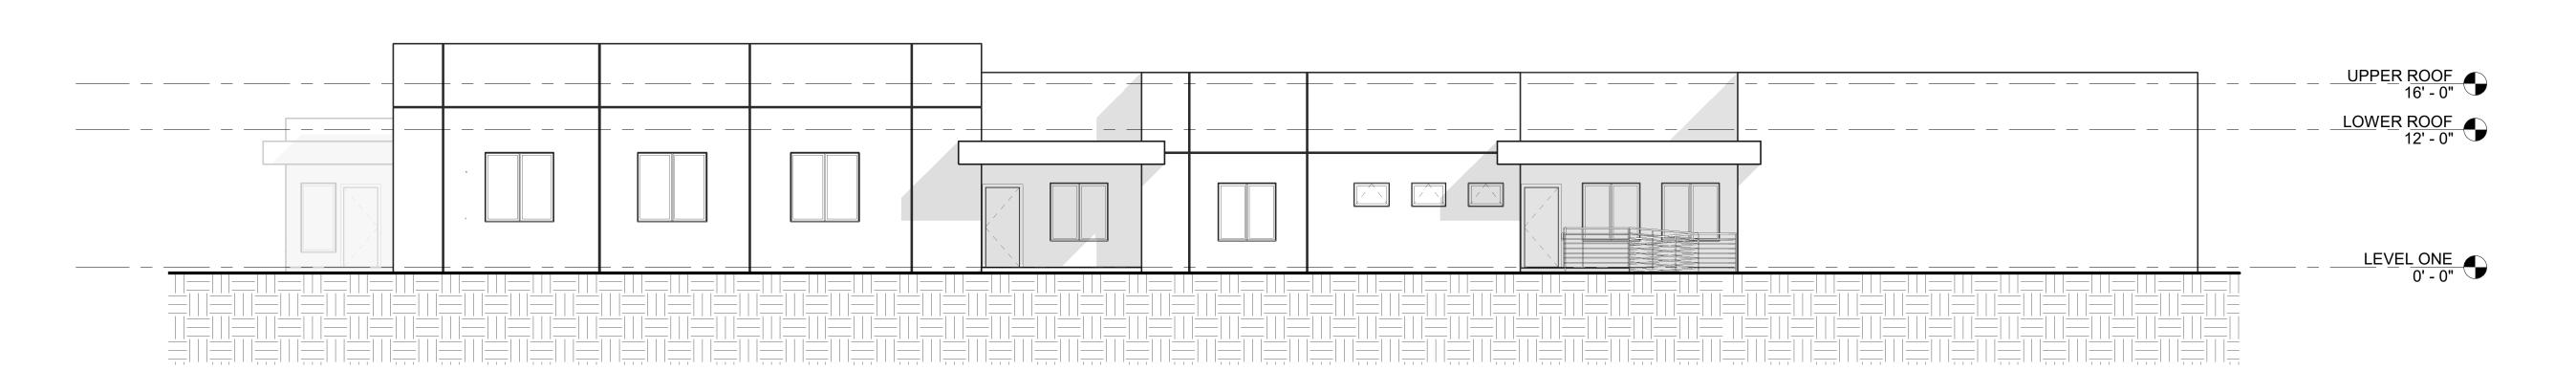

2 EAST ELEVATION
1/8" = 1'-0"





PRIME ARCHITECT

JAREDIAN DESIGN GROUP

5143 PALM PASSAGE, SECOND FLOOR - SUITES B24-25 ST. THOMAS, USVI 00802

PHONE: 340-777-1600

EMAIL: jarediandesigngroup@gmail.com

CONSULTING ARCHITECT

BOSCHULTE ARCHITECTURE, LLC

PO Box 303190 St. Thomas, VI 00803

phone: (340) 777-2375 e-mail: info@boschulte.com website: www.boschulte.com




390


PROGRESS SET REVISIONS 2021.007.04 4/15/2025 JTB JTB Checked by


SOUTH ELEVATION & EAST ELEVATION

A201

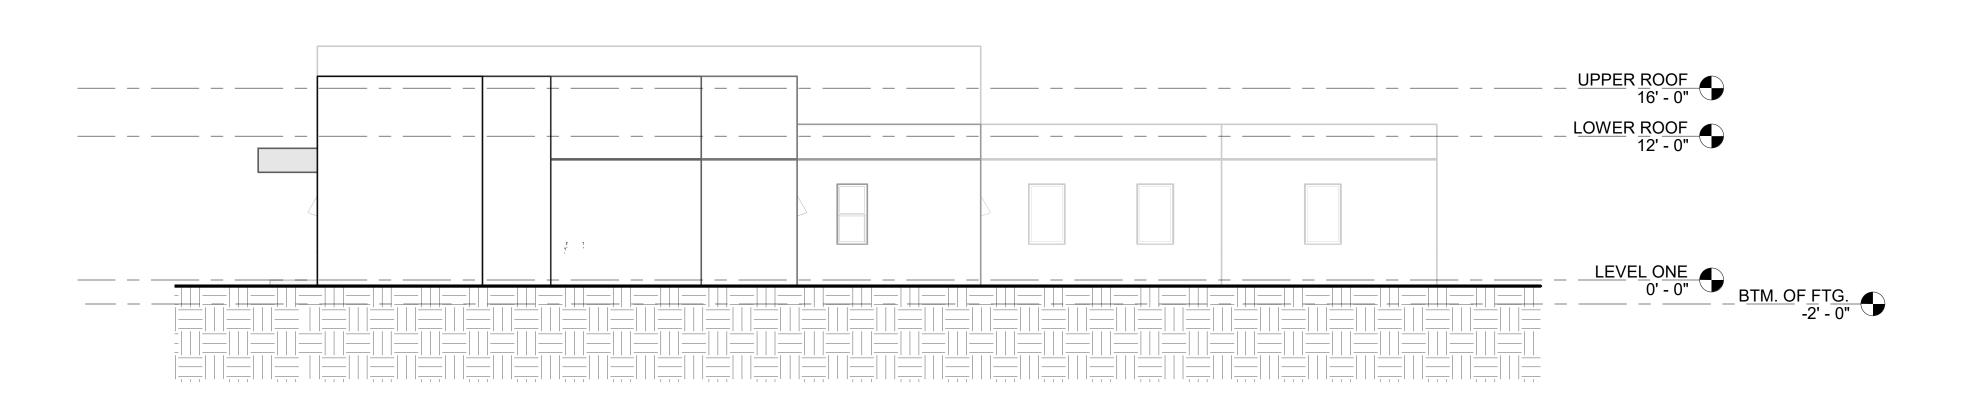
 
$$1 \frac{\text{NORTH ELEVATION}}{1/8" = 1'-0"}$$

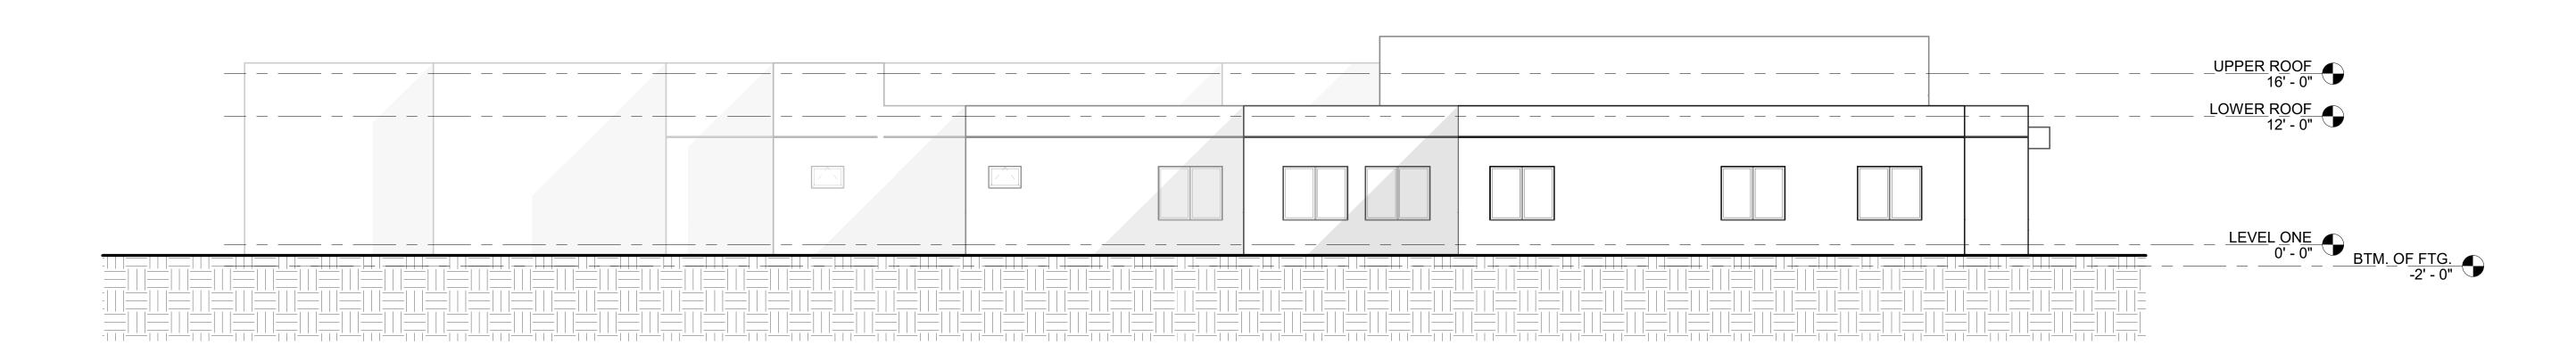







JAREDIAN DESIGN GROUP

5143 PALM PASSAGE, SECOND FLOOR - SUITES B24-25 ST. THOMAS, USVI 00802

PHONE: 340-777-1600

EMAIL: jarediandesigngroup@gmail.com CONSULTING ARCHITECT

BOSCHULTE ARCHITECTURE, LLC

PO Box 303190 St. Thomas, VI 00803

phone: (340) 777-2375 e-mail: info@boschulte.com website: www.boschulte.com



PRC	GRESS SET		
No.	Descrip	Description	
REV	ISIONS		
No.	Descript	Description	
Proje	ect number	2021.0	07.04
Proje			07.04 /2025
Date			

NORTH ELEVATION & WEST ELEVATION

A202



JAREDIAN DESIGN GROUP

5143 PALM PASSAGE, SECOND FLOOR - SUITES B24-25 ST. THOMAS, USVI 00802

PHONE: 340-777-1600

BOSCHULTE ARCHITECTURE

EMAIL: jarediandesigngroup@gmail.com CONSULTING ARCHITECT

BOSCHULTE ARCHITECTURE, LLC

PO Box 303190 St. Thomas, VI 00803

phone: (340) 777-2375 e-mail: info@boschulte.com website: www.boschulte.com



GEORGE C. SCOTT
FIRE STATION
LIMA COMPANY
ESTATE ANNAS RETREA
ST. THOMAS, U.S.V.I. 390


PROGRESS SET REVISIONS

2021.007.04 4/15/2025 JTB JTB

Checked by

BUILDING SECTIONS

A301 AS SHOWN

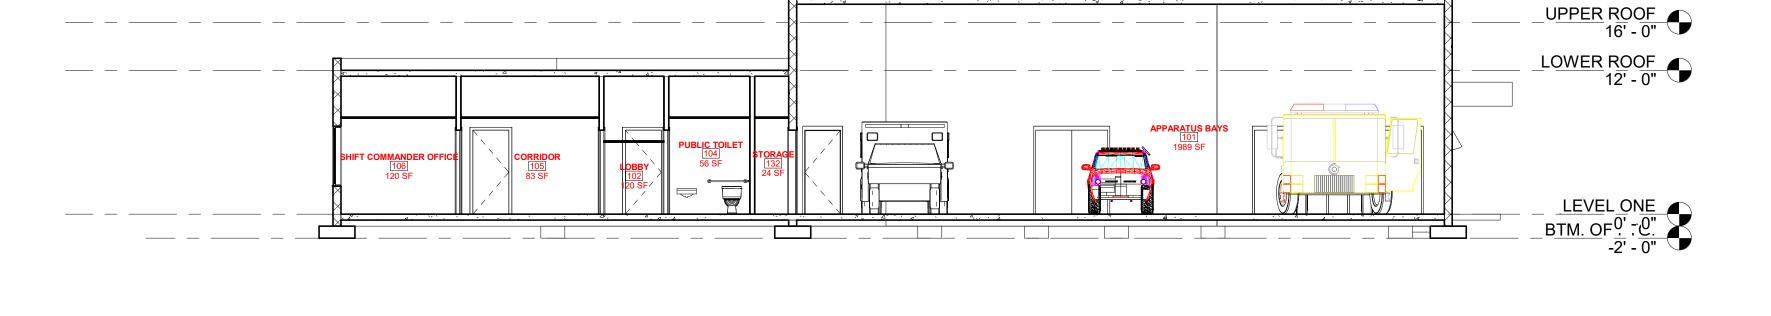

Section 1

1/8" = 1'-0"



Section 2

1/8" = 1'-0"





JAREDIAN DESIGN GROUP

5143 PALM PASSAGE, SECOND FLOOR - SUITES B24-25 ST. THOMAS, USVI 00802

PHONE: 340-777-1600

EMAIL: jarediandesigngroup@gmail.com

CONSULTING ARCHITECT

BOSCHULTE ARCHITECTURE, LLC

PO Box 303190 St. Thomas, VI 00803

phone: (340) 777-2375 e-mail: info@boschulte.com website: www.boschulte.com



390


PROGRESS SET REVISIONS 2021.007.04 4/15/2025 JTB JTB

BUILDING SECTIONS


A302


AS SHOWN

Checked by

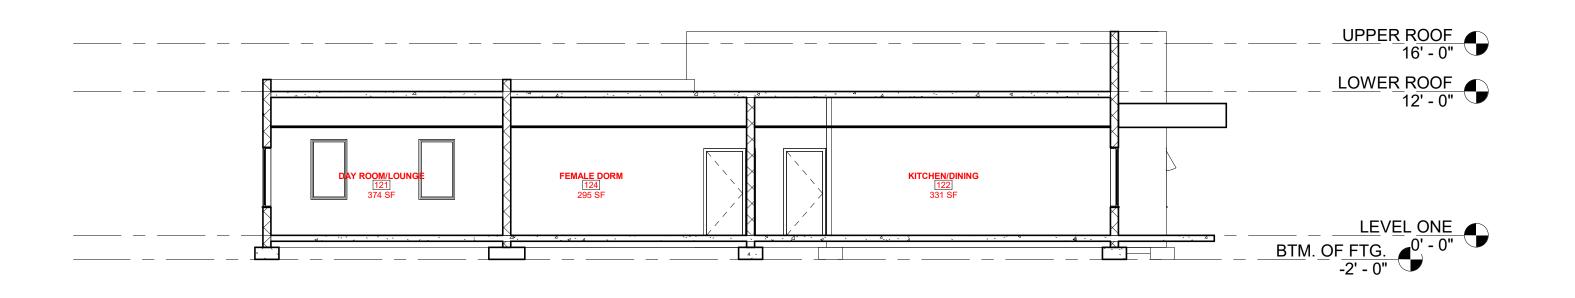


1 Section 3 1/8" = 1'-0"

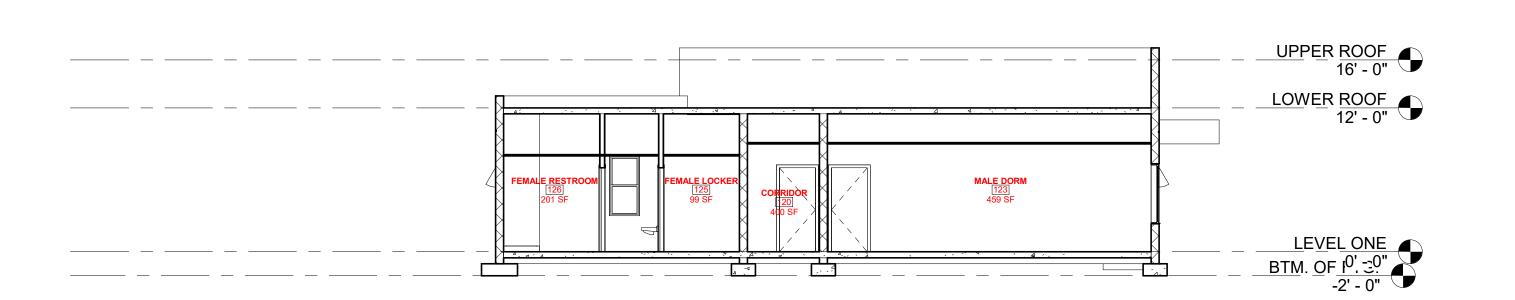

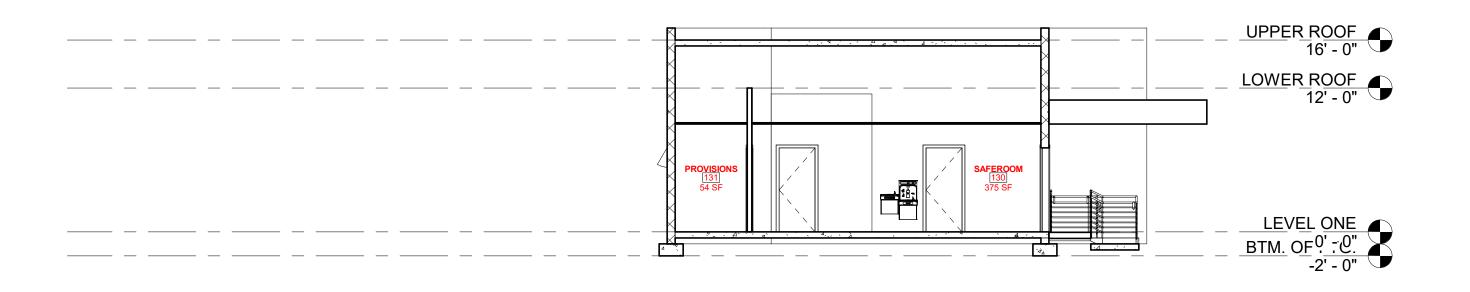

Section 5 1/8" = 1'-0"

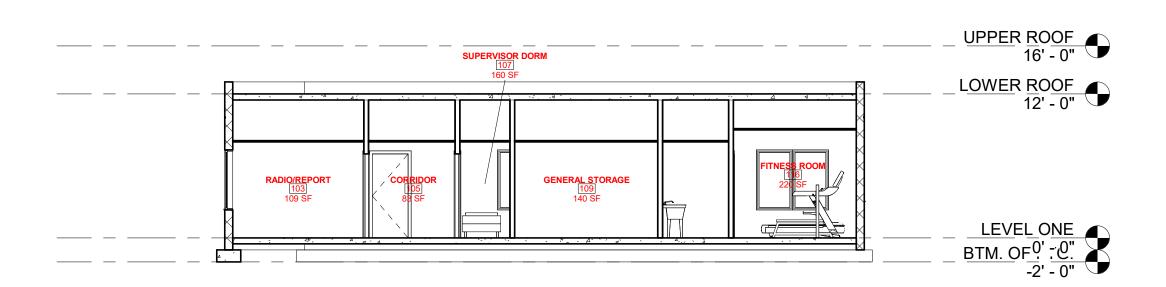

Section 6 1/8" = 1'-0"





PRIME ARCHITECT

JAREDIAN DESIGN GROUP

5143 PALM PASSAGE, SECOND FLOOR - SUITES B24-25 ST. THOMAS, USVI 00802

PHONE: 340-777-1600

EMAIL: jarediandesigngroup@gmail.com

CONSULTING ARCHITECT

BOSCHULTE ARCHITECTURE, LLC

PO Box 303190 St. Thomas, VI 00803

phone: (340) 777-2375 e-mail: info@boschulte.com website: www.boschulte.com



GEORGE C. SCOTT FIRE STATION LIMA COMPANY ESTATE ANNAS RETREA ST. THOMAS, U.S.V.I. 390 EST/ ST.

		\mathcal{C}	
PR	OGRESS SET		
No.	Descrip	otion	Date
RE	VISIONS		
No.	Descrip	otion	Date
		·	
Pro	oject number	2021.0	07.04
Da	te	4/15	/2025


BUILDING SECTIONS

JTB JTB


AS SHOWN

A303

Checked by

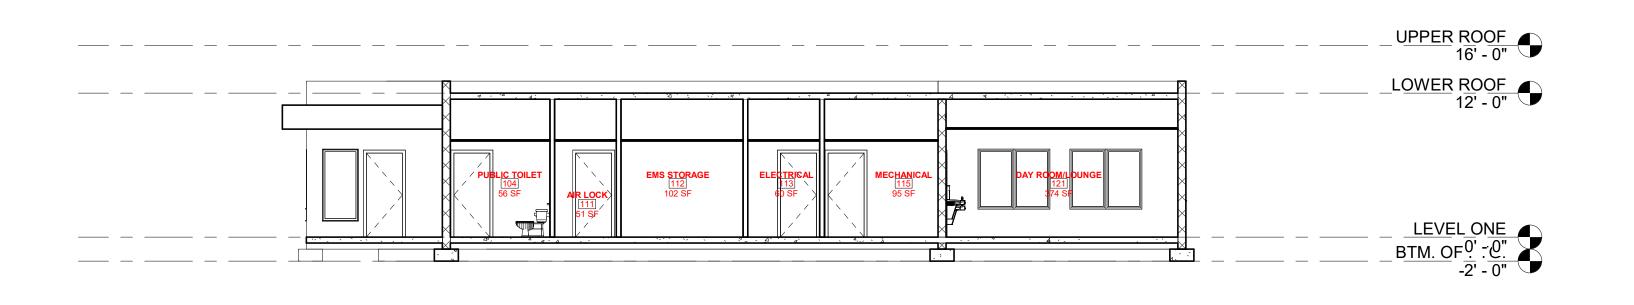

Section 7 1/8" = 1'-0"

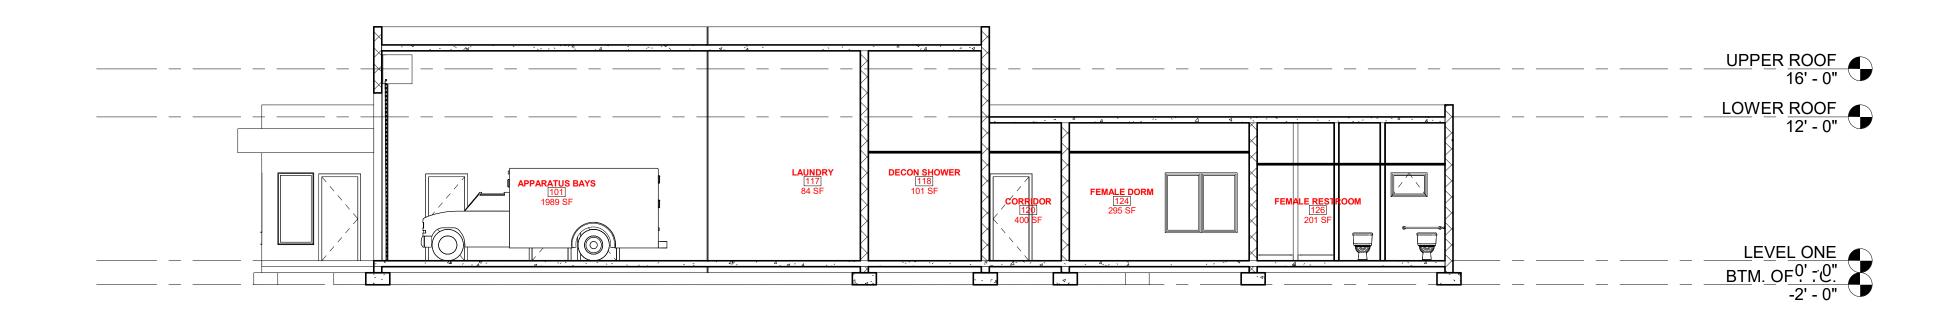

Section 8 1/8" = 1'-0"





PRIME ARCHITECT

JAREDIAN DESIGN GROUP

5143 PALM PASSAGE, SECOND FLOOR - SUITES B24-25 ST. THOMAS, USVI 00802

PHONE: 340-777-1600

EMAIL: jarediandesigngroup@gmail.com

CONSULTING ARCHITECT

BOSCHULTE ARCHITECTURE, LLC

PO Box 303190 St. Thomas, VI 00803

phone: (340) 777-2375 e-mail: info@boschulte.com website: www.boschulte.com




GEORGE C. SCOTT FIRE STATION LIMA COMPANY ESTATE ANNAS RETREA ST. THOMAS, U.S.V.I. 390


PROGRESS SET REVISIONS 2021.007.04 4/15/2025 JTB JTB Checked by

BUILDING SECITONS

A304

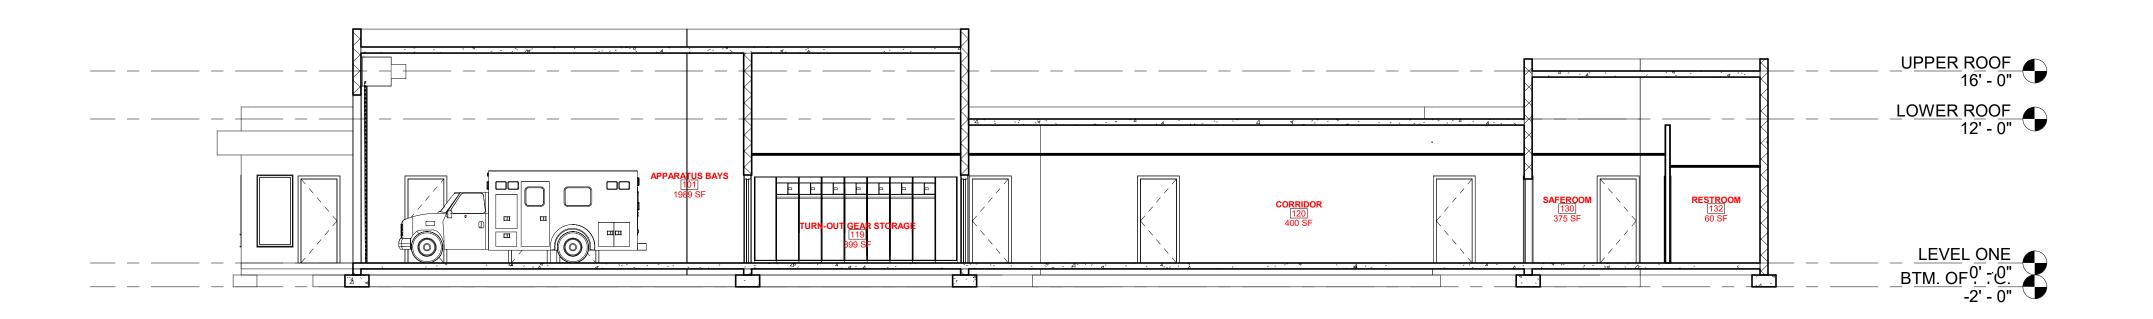

 $\frac{\text{Section 9}}{1/8" = 1'-0"}$

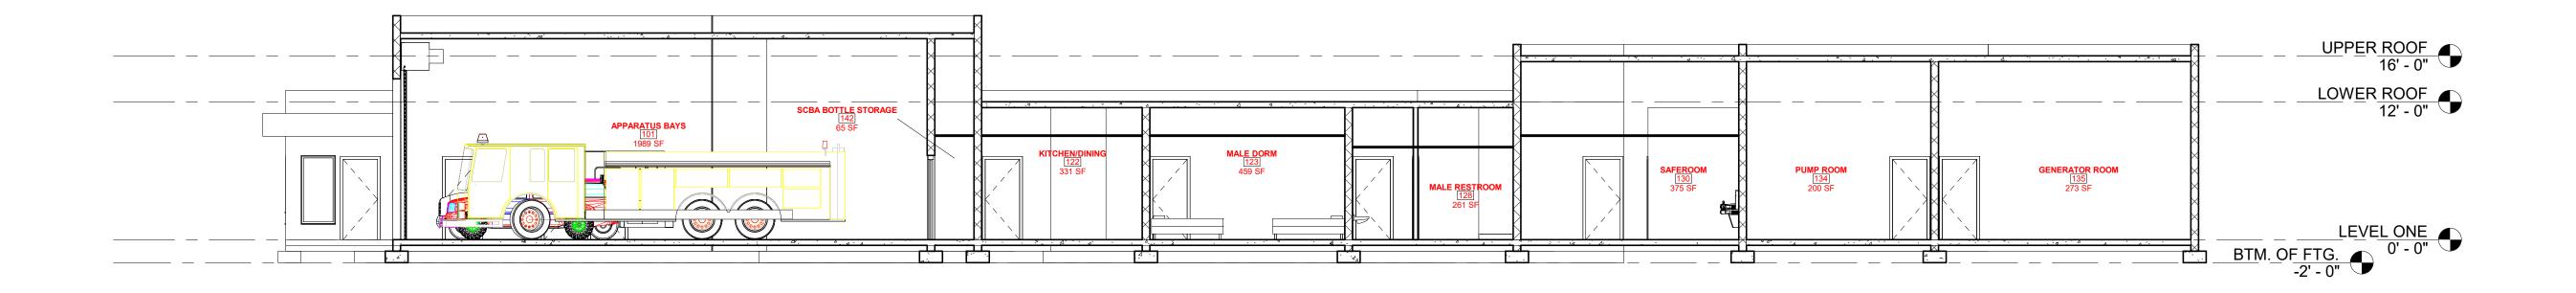

Section 10 1/8" = 1'-0"





PRIME ARCHITECT

JAREDIAN DESIGN GROUP

5143 PALM PASSAGE, SECOND FLOOR - SUITES B24-25 ST. THOMAS, USVI 00802

PHONE: 340-777-1600

EMAIL: jarediandesigngroup@gmail.com

CONSULTING ARCHITECT

BOSCHULTE ARCHITECTURE, LLC

PO Box 303190 St. Thomas, VI 00803

phone: (340) 777-2375 e-mail: info@boschulte.com website: www.boschulte.com



GEORGE C. SCOTT FIRE STATION LIMA COMPANY 390 ESTATE ANNAS RETREA ST. THOMAS, U.S.V.I.

		39			
PR	OGRESS SET				
No.	Descripti	Date			
1	SCHEMATIC DESIGN		08/17/24		
RE	VISIONS				
No.	Descripti	Date			
Dro	ject number	2024.0	07.04		
Dat		2021.007.04 4/15/2025			
Dra	wn by	JTB			
Che	ecked by	JTB			

BUILDING SECTIONS

A305

Scale:

	DOOR SC	HEDUL	E			
OR MARK	DESCRIPTION	WIDTH	HEIGHT	THICKNESS	FUNCTION	COMMENTS
1A	Door-StormDefender-FaceOfWallMount Cornell: 12' WIDE x 14' HIGH	12' - 0"	17' - 2"		Interior	
1B	Door-StormDefender-FaceOfWallMount Cornell: 12' WIDE x 14' HIGH	12' - 0"	17' - 2"		Interior	
1C	Door-StormDefender-FaceOfWallMount_Cornell: 14' WIDE x 14' HIGH 2	14' - 0"	17' - 2"		Interior	
2A	Single-Flush_Swing: 36" x 84" INT	3' - 0"	7' - 0"	0' - 1 3/8"	Interior	
3A	Single-Flush_Swing: 36" x 84" INT	3' - 0"	7' - 0"	0' - 1 3/8"	Interior	
4A	Single-Flush_Swing: 36" x 84" INT	3' - 0"	7' - 0"	0' - 1 3/8"	Interior	
5A	Single-Flush_Swing: 36" x 84" INT	3' - 0"	7' - 0"	0' - 1 3/8"	Interior	
6A	Single-Flush_Swing: 36" x 84" INT	3' - 0"	7' - 0"	0' - 1 3/8"	Interior	
	Single-Flush_Swing: 36" x 84" INT	3' - 0"	7' - 0"	0' - 1 3/8"	Interior	
8A	Single-Flush_Swing: 36" x 84" INT	3' - 0"	7' - 0"	0' - 1 3/8"	Interior	
0A	Single-Flush_Swing: 36" x 84" INT	3' - 0"	7' - 0"	0' - 1 3/8"	Interior	
	Single-Flush_Swing: 36" x 84" INT	3' - 0"	7' - 0"	0' - 1 3/8"	Interior	
1A		3' - 0"	7' - 0"	0' - 1 3/8"		
1B	Single-Flush_Swing: 36" x 84" INT	3' - 0"	7' - 0"	0' - 1 3/8"	Interior	
2A	Single-Flush_Swing: 36" x 84" INT Single-Flush Swing: 36" x 84" INT	3' - 0"	7' - 0"	0' - 1 3/8"	Interior	
					Interior	
3A	Single-Flush_Swing: 36" x 84" INT	3' - 0"	7' - 0"	0' - 1 3/8"	Interior	
4A	Single-Flush_Swing: 36" x 84" INT	3' - 0"	7' - 0"	0' - 1 3/8"	Interior	
5A	Single-Flush_Swing: 36" x 84" INT	3' - 0"	7' - 0"	0' - 1 3/8"	Interior	
6A	Single-Flush_Swing: 36" x 84" INT	3' - 0"	7' - 0"	0' - 1 3/8"	Interior	
BA	Door-Passage-Single-Flush: 36" x 84"	3' - 0"	7' - 0"	0' - 1 3/4"	Exterior	
9A	Door-Passage-Double-Flush: 72" x 84"	6' - 0"	7' - 0"	0' - 1 3/4"	Exterior	
9B	Door-Passage-Double-Flush: 72" x 84"	6' - 0"	7' - 0"	0' - 1 3/4"	Exterior	
1A	Single-Flush_Swing: 36" x 84" INT	3' - 0"	7' - 0"	0' - 1 3/8"	Interior	
1B	Single-Flush_Swing: 36" x 84" INT	3' - 0"	7' - 0"	0' - 1 3/8"	Interior	
	Single-Flush_Swing: 36" x 84" INT	3' - 0"	7' - 0"	0' - 1 3/8"	Interior	
3A	Single-Flush_Swing: 36" x 84" INT	3' - 0"	7' - 0"	0' - 1 3/8"	Interior	
4A	Single-Flush_Swing: 36" x 84" INT	3' - 0"	7' - 0"	0' - 1 3/8"	Interior	
5A	Single-Flush_Swing: 36" x 84" INT	3' - 0"	7' - 0"	0' - 1 3/8"	Interior	
6A	Single-Flush_Swing: 36" x 84" INT	3' - 0"	7' - 0"	0' - 1 3/8"	Interior	
6B	Single-Flush_Swing: 36" x 84" INT	3' - 0"	7' - 0"	0' - 1 3/8"	Interior	
6C	Single-Flush_Swing: 30" x 80"	2' - 6"	6' - 8"	0' - 1 3/8"	Interior	
	Single-Flush_Swing: 36" x 84" INT	3' - 0"	7' - 0"	0' - 1 3/8"	Interior	
ВА	Single-Flush_Swing: 36" x 84" INT	3' - 0"	7' - 0"	0' - 1 3/8"	Interior	
8B	Single-Flush_Swing: 36" x 84" INT	3' - 0"	7' - 0"	0' - 1 3/8"	Interior	
8C	Single-Flush_Swing: 36" x 84" INT	3' - 0"	7' - 0"	0' - 1 3/8"	Interior	
BD	Single-Flush_Swing: 24" x 80"	2' - 0"	6' - 8"	0' - 1 3/8"	Interior	
3E	Single-Flush_Swing: 24" x 80"	2' - 0"	6' - 8"	0' - 1 3/8"	Interior	
9A	Single-Flush_Swing: 36" x 84" INT	3' - 0"	7' - 0"	0' - 1 3/8"	Interior	
)A	Single-Flush_Swing: 36" x 84" INT	3' - 0"	7' - 0"	0' - 1 3/8"	Interior	
0B	Single-Flush_Swing: 36" x 84" INT	3' - 0"	7' - 0"	0' - 1 3/8"	Interior	
1A	Single-Flush_Swing: 36" x 84" INT	3' - 0"	7' - 0"	0' - 1 3/8"	Interior	
2A	Single-Flush_Swing: 36" x 84" INT	3' - 0"	7' - 0"	0' - 1 3/8"	Interior	
2A	Single-Flush_Swing: 36" x 84" INT	3' - 0"	7' - 0"	0' - 1 3/8"	Interior	
3A	Single-Flush_Swing: 36" x 84" INT	3' - 0"	7' - 0"	0' - 1 3/8"	Interior	
4A	Single-Flush_Swing: 36" x 84" INT	3' - 0"	7' - 0"	0' - 1 3/8"	Interior	
5A	Single-Flush_Swing: 36" x 84" INT	3' - 0"	7' - 0"	0' - 1 3/8"	Interior	
0A	Single-Flush Swing: 36" x 84" INT	3' - 0"	7' - 0"	0' - 1 3/8"	Interior	
2A	Door-Passage-Double-Flush: 72" x 84"	6' - 0"	7' - 0"	0' - 1 3/4"	Exterior	
2B	Door-Passage-Double-Flush: 72" x 84"	6' - 0"	7' - 0"	0' - 1 3/4"	Exterior	
4A	Single-Flush_Swing: 36" x 84" INT	3' - 0"	7' - 0"	0' - 1 3/8"	Interior	
and total: 50		100	ı. Ü			





JAREDIAN DESIGN GROUP

5143 PALM PASSAGE, SECOND FLOOR - SUITES B24-25 ST. THOMAS, USVI 00802

PHONE: 340-777-1600

EMAIL: jarediandesigngroup@gmail.com

CONSULTING ARCHITECT

BOSCHULTE ARCHITECTURE, LLC

PO Box 303190 St. Thomas, VI 00803

phone: (340) 777-2375 e-mail: info@boschulte.com website: www.boschulte.com

GEORGE C. SCOTT FIRE STATION LIMA COMPANY 390 ESTATE ANNAS RETREA ST. THOMAS, U.S.V.I.

PR	OGRESS SET						
No.	Descrip	Date					
RF	VISIONS						
No.							
110.	Безспр	7.11011	Date				
Pro	ject number	2021.0	07.04				
Dat	te	4/15/	4/15/2025				
Dra	ıwn by		JTB				
Ch	acked by		ITD				

DOOR SCHEDULE

A501

Window Schedule									
	Rough Opening		Detail						
Type Mark	Width	Height	Туре	Head	Jamb	Sill	Comments		
1	2' - 6"	5' - 0"	Double Hung						
3	3' - 0"	2' - 0"	Window-Awning-Single						
5	2' - 6"	5' - 0"	Instance-Window-Fixed						
6	3' - 0"	5' - 0"	Instance-Window-Fixed						
13	3' - 0"	6' - 0"	Instance-Window-Fixed						
16	<varies></varies>	<varies></varies>	Instance-Window-Fixed						





JAREDIAN DESIGN GROUP

5143 PALM PASSAGE, SECOND FLOOR - SUITES B24-25 ST. THOMAS, USVI 00802

PHONE: 340-777-1600

EMAIL: jarediandesigngroup@gmail.com

CONSULTING ARCHITECT

BOSCHULTE ARCHITECTURE, LLC

PO Box 303190 St. Thomas, VI 00803

phone: (340) 777-2375 e-mail: info@boschulte.com website: www.boschulte.com



390

PROGRESS SET REVISIONS 2021.007.04

WINDOW SCHEDULE

4/15/2025

AS SHOWN

JTB JTB

A502

Checked by

ROOM FINISH SCHEDULE									
ROOM									
NUMBER	ROOM NAME	FLOOR	BASE	CEILING	NORTH	EAST	SOUTH	WEST	COMMENTS
101	APPARATUS BAYS	CONCRETE/EPOXY	NONE	OPEN STRUCTURE	PAINT	PAINT	PAINT	PAINT	
102	LOBBY	TILE	TILE	ACT	PAINT	PAINT	PAINT	PAINT	
103	RADIO/REPORT	TILE	TILE	ACT	PAINT	PAINT	PAINT	PAINT	
104	PUBLIC TOILET	TILE	TILE	GYP. BOARD	PAINT	PAINT	PAINT	PAINT	
105	CORRIDOR	TILE	TILE	ACT	PAINT	PAINT	PAINT	PAINT	
106	SHIFT COMMANDER OFFICE	TILE	TILE	ACT	PAINT	PAINT	PAINT	PAINT	
107	SUPERVISOR DORM	TILE	TILE	ACT	PAINT	PAINT	PAINT	PAINT	
108	SUPERVISOR BATH	TILE	TILE	GYP. BOARD	PAINT	PAINT	PAINT	PAINT	
109	GENERAL STORAGE	TILE	TILE	ACT	PAINT	PAINT	PAINT	PAINT	
110	CORR.	TILE	TILE	ACT	PAINT	PAINT	PAINT	PAINT	
111	AIR LOCK	TILE	TILE	GYP. BOARD	PAINT	PAINT	PAINT	PAINT	
112	EMS STORAGE	CONCRETE/EPOXY	NONE	ACT	PAINT	PAINT	PAINT	PAINT	
113	ELECTRICAL	CONCRETE/EPOXY	NONE	GYP. BOARD	PAINT	PAINT	PAINT	PAINT	
114	JANITOR	TILE	TILE	GYP. BOARD	PAINT	PAINT	PAINT	PAINT	
115	MECHANICAL	CONCRETE/EPOXY	NONE	GYP. BOARD	PAINT	PAINT	PAINT	PAINT	
116	FITNESS ROOM	CONCRETE/EPOXY	NONE	ACT	PAINT	PAINT	PAINT	PAINT	
117	LAUNDRY		NONE	GYP. BOARD	PAINT	PAINT	PAINT	PAINT	
118	DECON SHOWER	CONCRETE/EPOXY	NONE	GYP. BOARD	PAINT	PAINT	PAINT	PAINT	
119	TURN-OUT GEAR STORAGE	CONCRETE/EPOXY	NONE	GYP. BOARD	PAINT	PAINT	PAINT	PAINT	
120	CORRIDOR	TILE	TILE	ACT	PAINT	PAINT	PAINT	PAINT	
121	DAY ROOM/LOUNGE	TILE	TILE	ACT	PAINT	PAINT	PAINT	PAINT	
122	KITCHEN/DINING	TILE	TILE	GYP. BOARD	PAINT	PAINT	PAINT	PAINT	
123	MALE DORM	TILE	TILE	ACT	PAINT	PAINT	PAINT	PAINT	
124	FEMALE DORM	TILE	TILE	ACT	PAINT	PAINT	PAINT	PAINT	
125	FEMALE LOCKER	TILE	TILE	GYP. BOARD	PAINT	PAINT	PAINT	PAINT	
126	FEMALE RESTROOM	TILE	TILE	GYP. BOARD	PAINT	PAINT	PAINT	PAINT	
127	MALE LOCKER	TILE	TILE	GYP. BOARD	PAINT	PAINT	PAINT	PAINT	
128	MALE RESTROOM	TILE	TILE	GYP. BOARD	PAINT	PAINT	PAINT	PAINT	
129	STORAGE CLOSET	TILE	TILE	ACT	PAINT	PAINT	PAINT	PAINT	
130	SAFEROOM	TILE	TILE	ACT	PAINT	PAINT	PAINT	PAINT	
131	PROVISIONS	TILE	TILE	ACT	PAINT	PAINT	PAINT	PAINT	
132	STORAGE	TILE	TILE	GYP. BOARD	PAINT	PAINT	PAINT	PAINT	
132	RESTROOM	TILE	TILE	GYP. BOARD	PAINT	PAINT	PAINT	PAINT	
133	CORR.	CONCRETE/EPOXY		CONCRETE CEILING	PAINT	PAINT	PAINT	PAINT	
134	PUMP ROOM	CONCRETE/EPOXY		CONCRETE CEILING	PAINT	PAINT	PAINT	PAINT	
135	GENERATOR ROOM	CONCRETE/EPOXY		CONCRETE CEILING	PAINT	PAINT	PAINT	PAINT	
142	SCBA BOTTLE STORAGE	CONCRETE/EPOXY		GYP. BOARD	PAINT	PAINT	PAINT	PAINT	
144	FITNESS ROOM TOILET	TILE	TILE	GYP. BOARD	PAINT	PAINT	PAINT	PAINT	
Grand total: 38	-		ı	'	1		<u>I</u>		

ROOM FINISHES LEGEND

- NEW PORCELAIN TILE FINISH

CONCRETE/EPOXY - CONCRETE FLOOR WITH EPOXY FLOOR FINISH

PAINT - PRIMED WITH (2) FINISH COATS OF PAINT

CONC - CONCRETE WITH PLASTER FINISH

OPEN STRUCTURE - EXPOSED STRUCTURE CEILING WITH DRYFALL PAINT FINISH (BLACK)

ACT - 2x2 ACOUSTICAL CEILING TILE IN SUSPENDED GRID

GYP. BOARD - SUSPENDED GYPSUM WALL BOARD FINISH

BOSCHULTE ARCHITECTURE



PRIME ARCHITECT

JAREDIAN DESIGN GROUP

5143 PALM PASSAGE, SECOND FLOOR - SUITES B24-25 ST. THOMAS, USVI 00802

PHONE: 340-777-1600

EMAIL: jarediandesigngroup@gmail.com

CONSULTING ARCHITECT

BOSCHULTE ARCHITECTURE, LLC

PO Box 303190 St. Thomas, VI 00803

phone: (340) 777-2375 e-mail: info@boschulte.com website: www.boschulte.com



FIRE STATION
LIMA COMPANY
390 ESTATE ANNAS RETRE
ST. THOMAS, U.S.V.I.

PROGRESS SET

No. Description Date

REVISIONS

No. Description Date

Project number 2021.007.04

Date 4/15/2025

ROOM FINISH SCHEDULE

JTB JTB

AS SHOWN

A503

cale:

Scale: